

Personal Printers

THE PAYMENT

2008/3 800/W 004E-104E

S9S1B1

Manufactures Code:

Revision Number:

Description	Count
Geyser Electric 200L Complete With Plumbing	1
Shower x 1 Complete With Plumbing/Curtain & Partition	2
Sink 1.200m Single Bowl Complete With Cupboards & Plumbing	1
Wash Hand Basin Porcelain Pedestal Complete With Plumbing -C&H water	2
WC Porcelain Close Couple Complete with Plumbing No Cubicle	2

Description	Count
Isolator Electric Geyser	1
Isolator Stove	1
Light Flour. Double 1.200m Open Channel	10
Light Internal Round Flat Bowl JD90	2
Plug Single 16Amp	8
Switch light 1 x 1 lever Complete With Cover	7


Door	
Description	Count
Door (Chromadek) Single Complete excluding Panel	1
Door (Hollow Core) Single Complete excluding Panel	6

Floor Sched	dule
Description	Area
Vinyl	66
Sheeting	m²


Windows	
Description	Count
Nindow A - 900mm x 900mm Top Hung - Clear Glass-4mm	6
Nindow E - 600mm x 600mm Top Hung - Obscure Glass-4mm	2

Furniture Schedule	
Description	Count
Base Unit 800mm	1
Draw unit (4 Drawer)	1
Wall Unit 800mm	1
Work Top	1
0200	

Description	Count
3 Tier Complete With Hand Rails Single Door	1
Large Tripod Jack with Concrete pads	12
Shell 7.060m x 9.300m	1

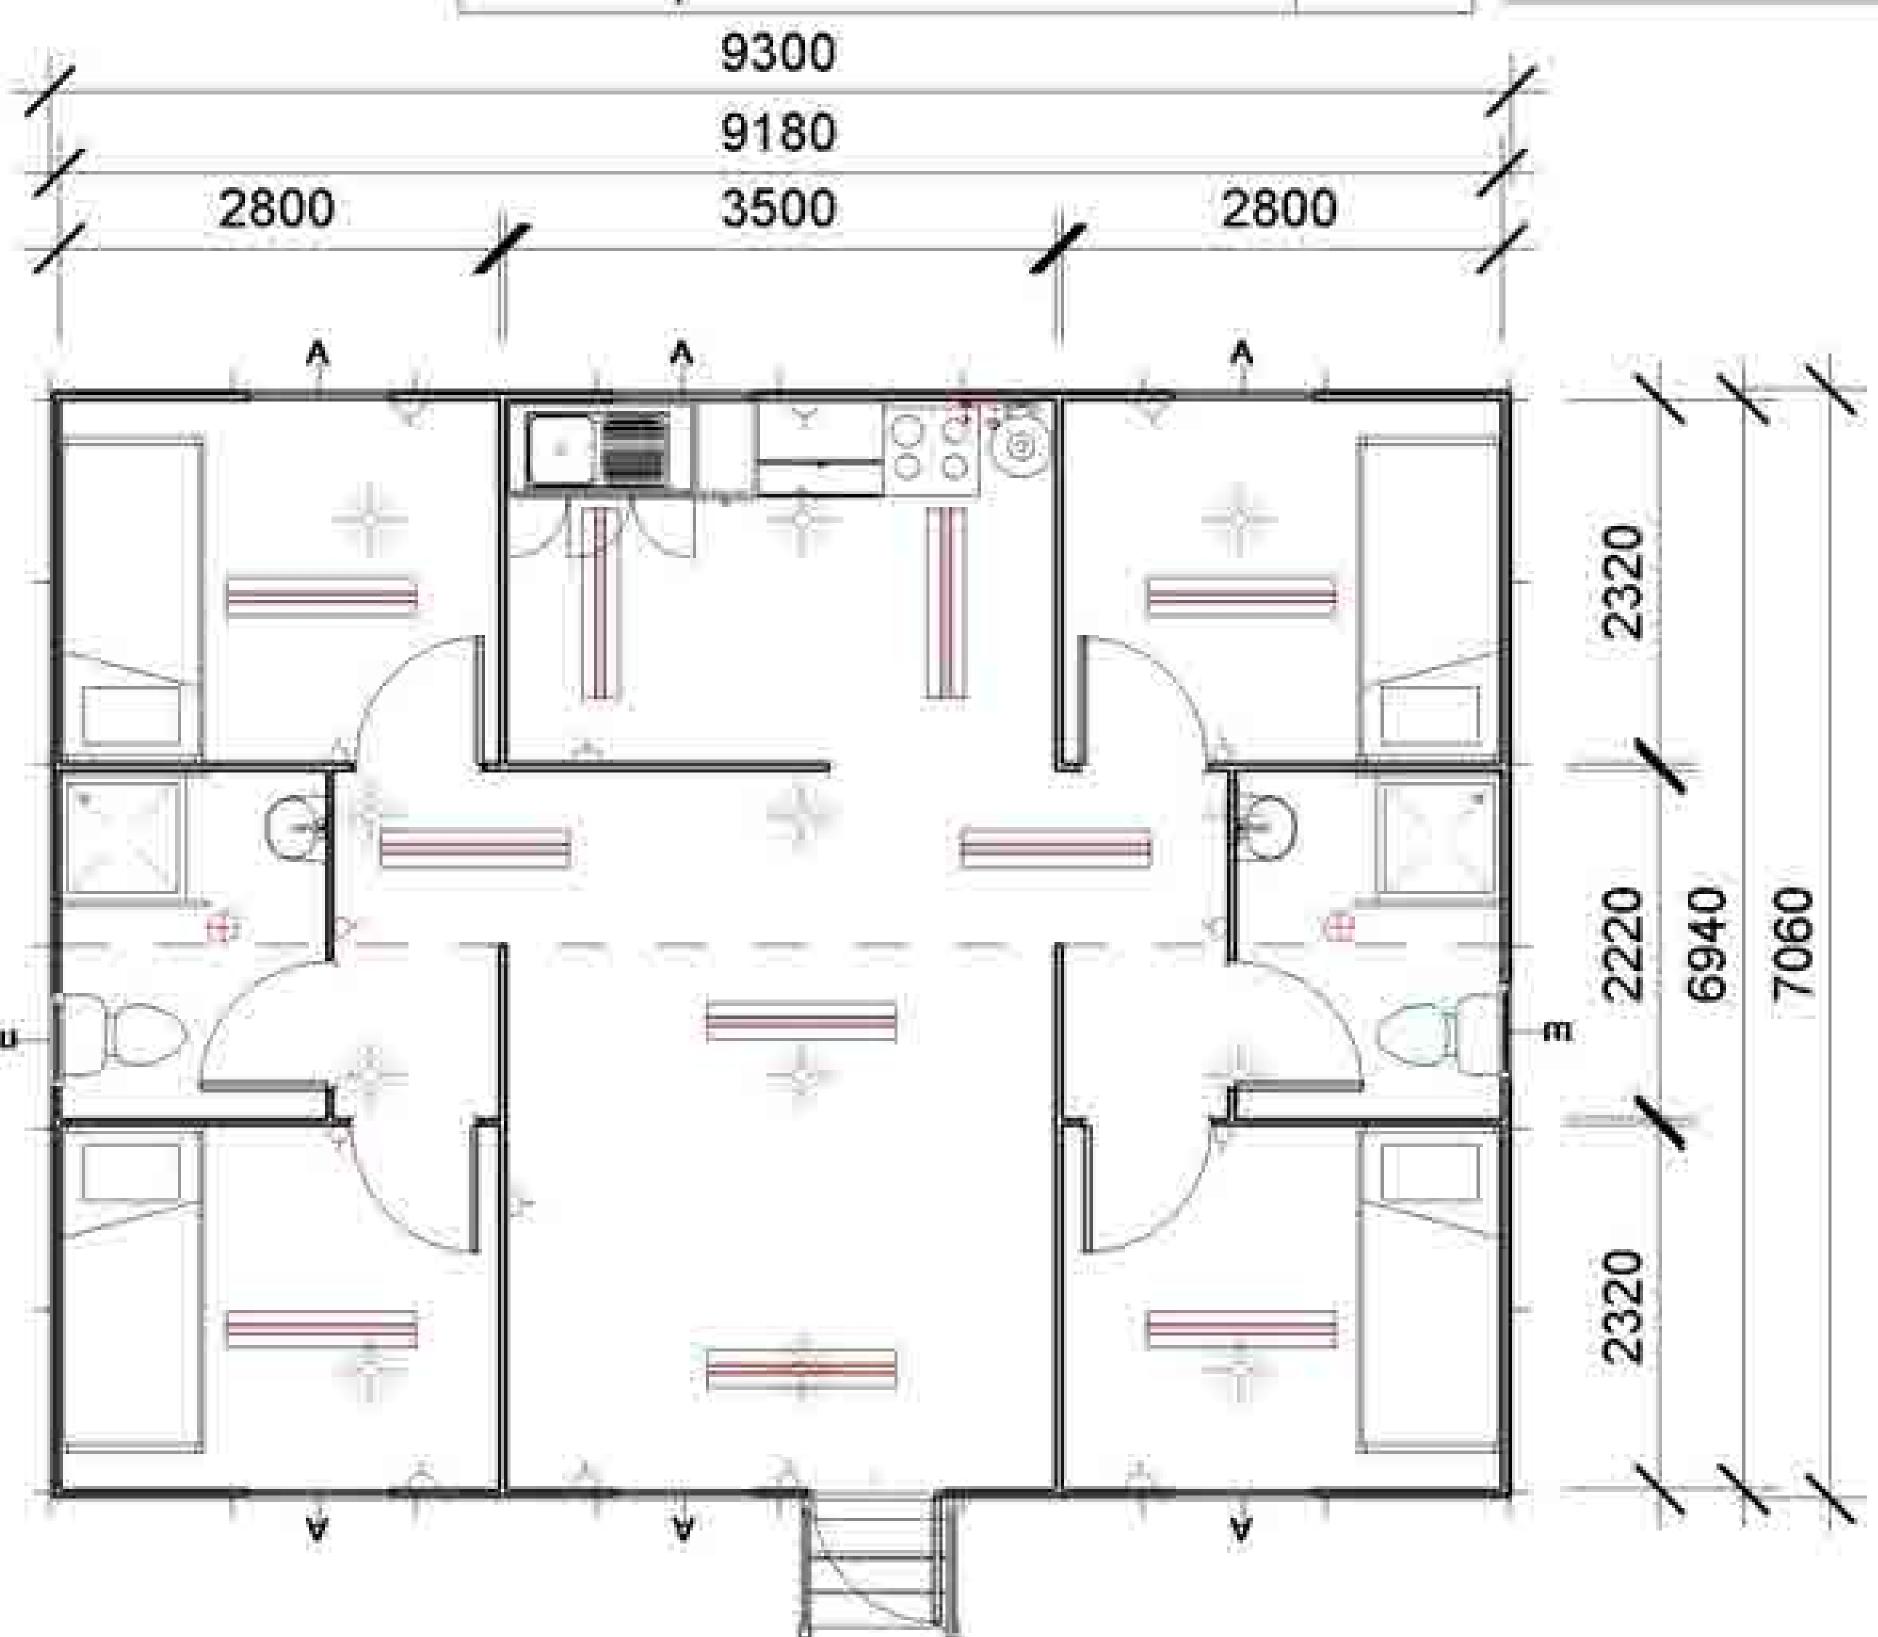

Floor Plan

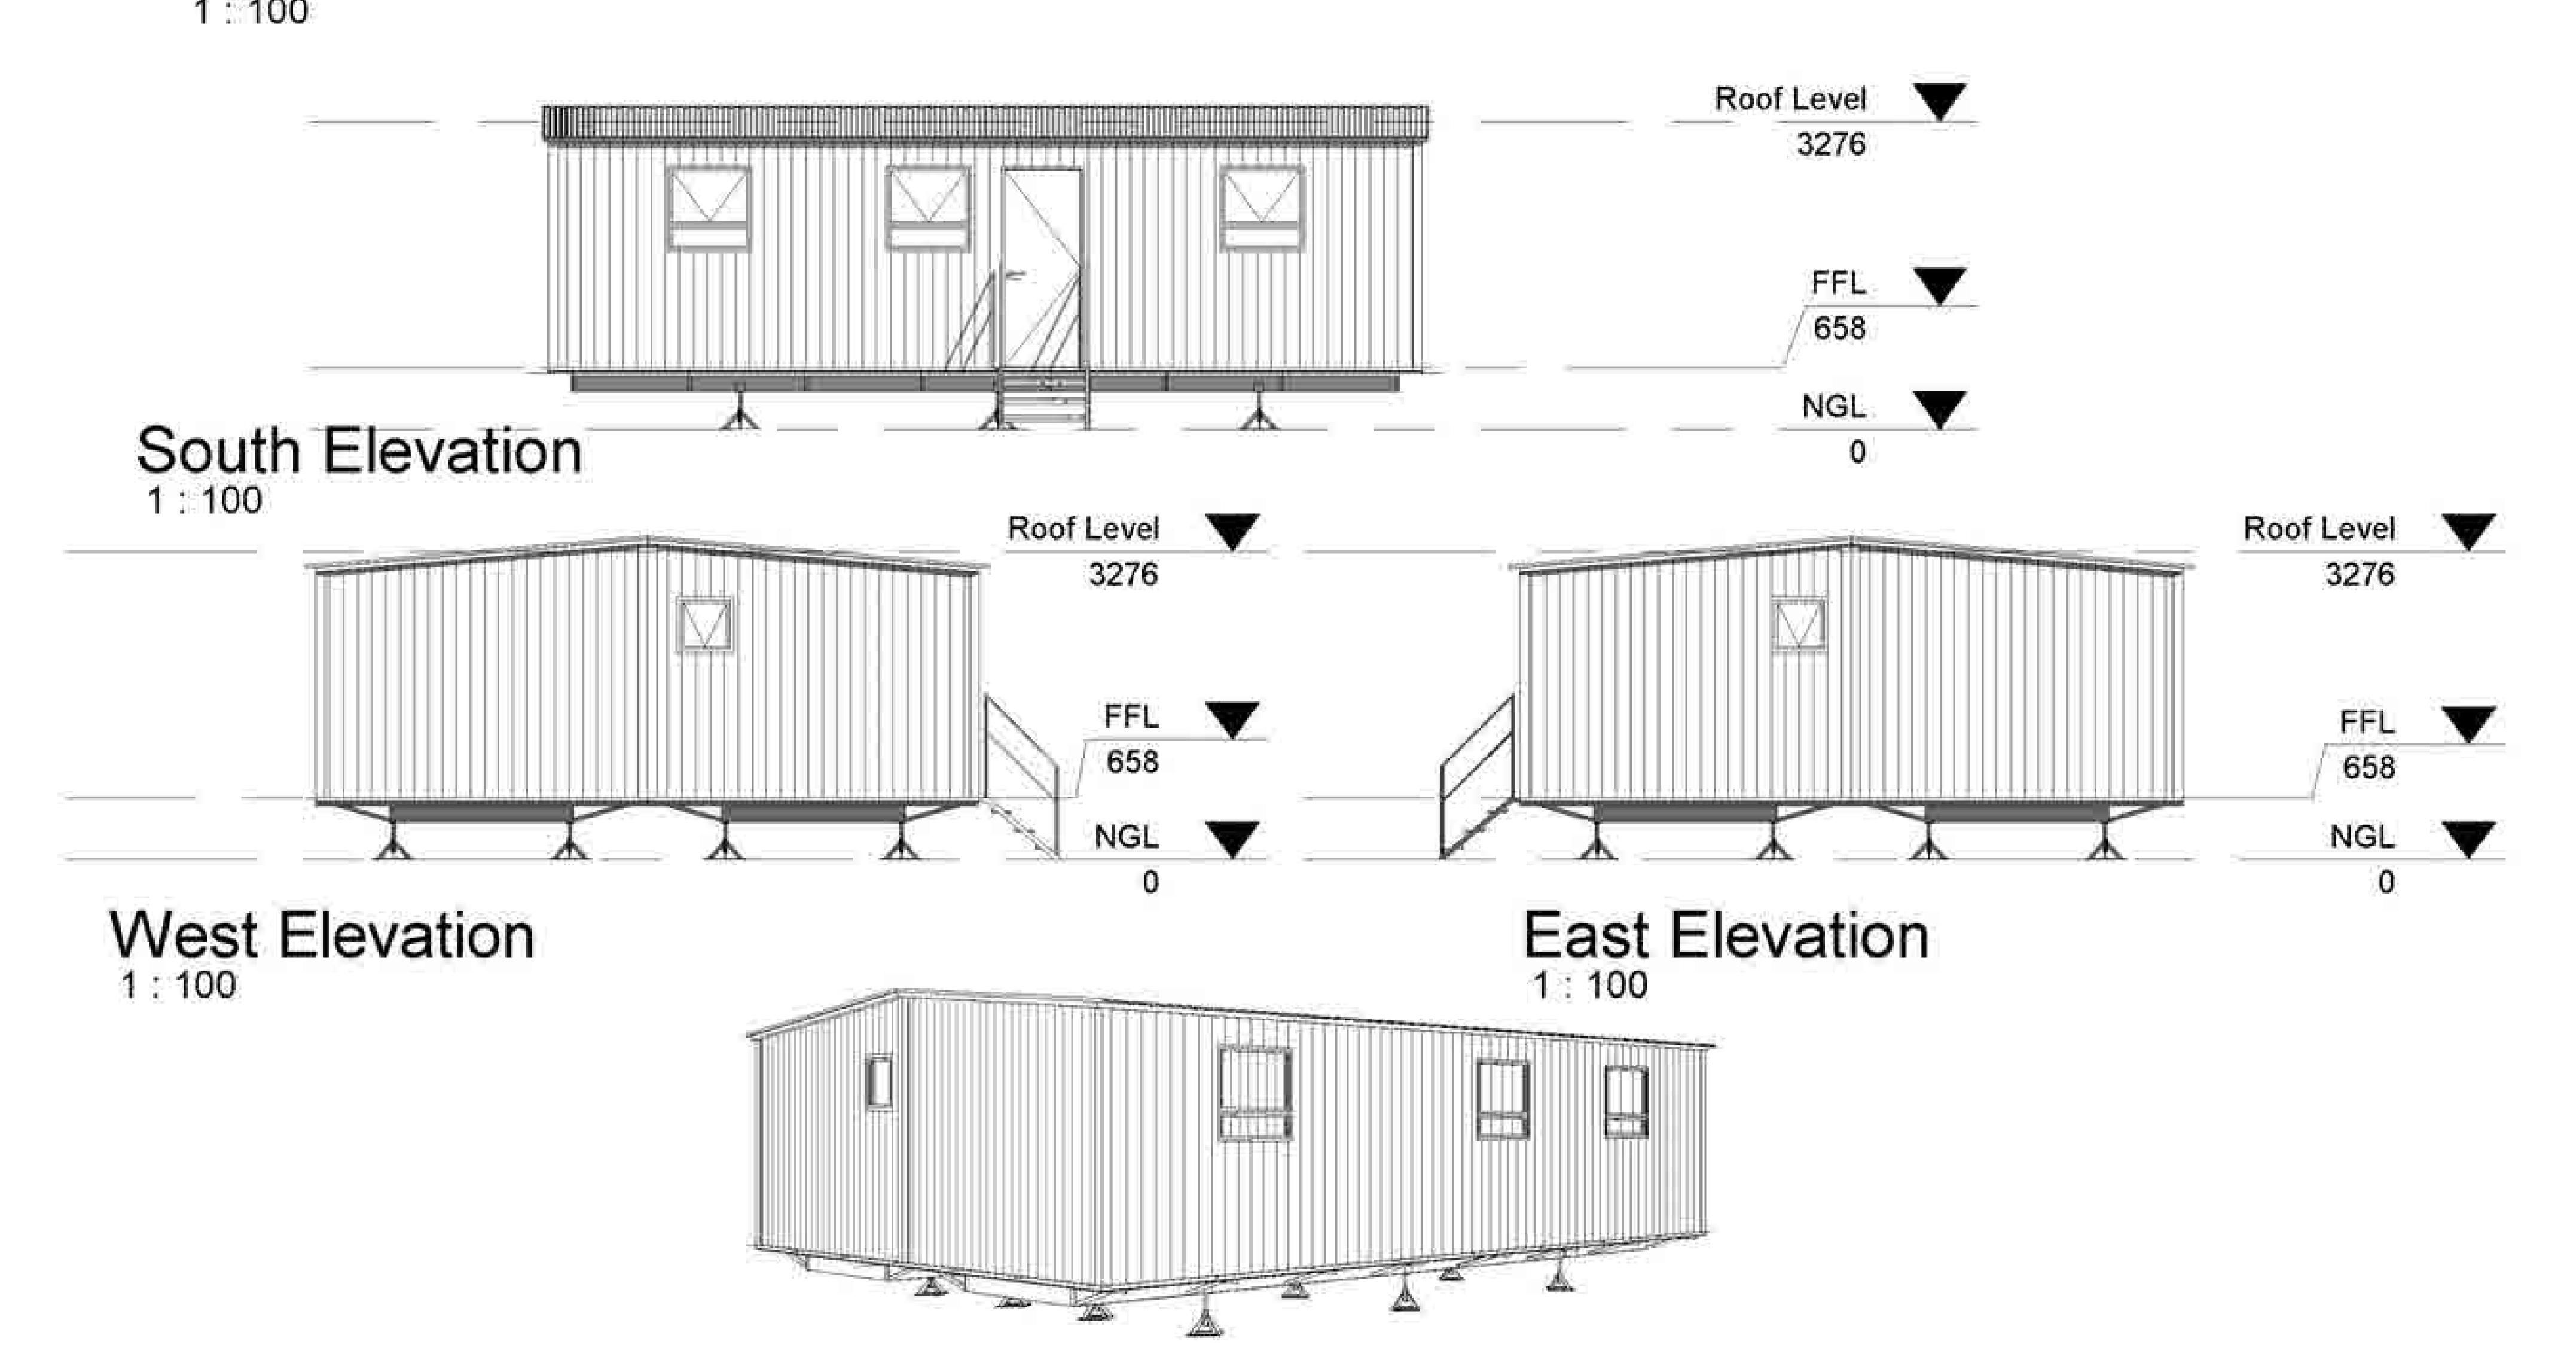



South africa Tel: +27 11 794 1340
Fax: +27 11 794 1347
speedspace@speedspace.co.za


Botswana Tel: +267 391 2537

www.speedspace.co.za


Tel: +267 391 2537 FAX: +267 391 3879 speedspace@info.bw

Pro

	Project Information	Drawing Information	Revision Number	Description	Date
	Client Name:	Prawing Description: RESIDENTIAL UNIT			
Š		Scale:			
	Project Address:	Drawing Number: R331			
		14/03/2016 17:00:02			

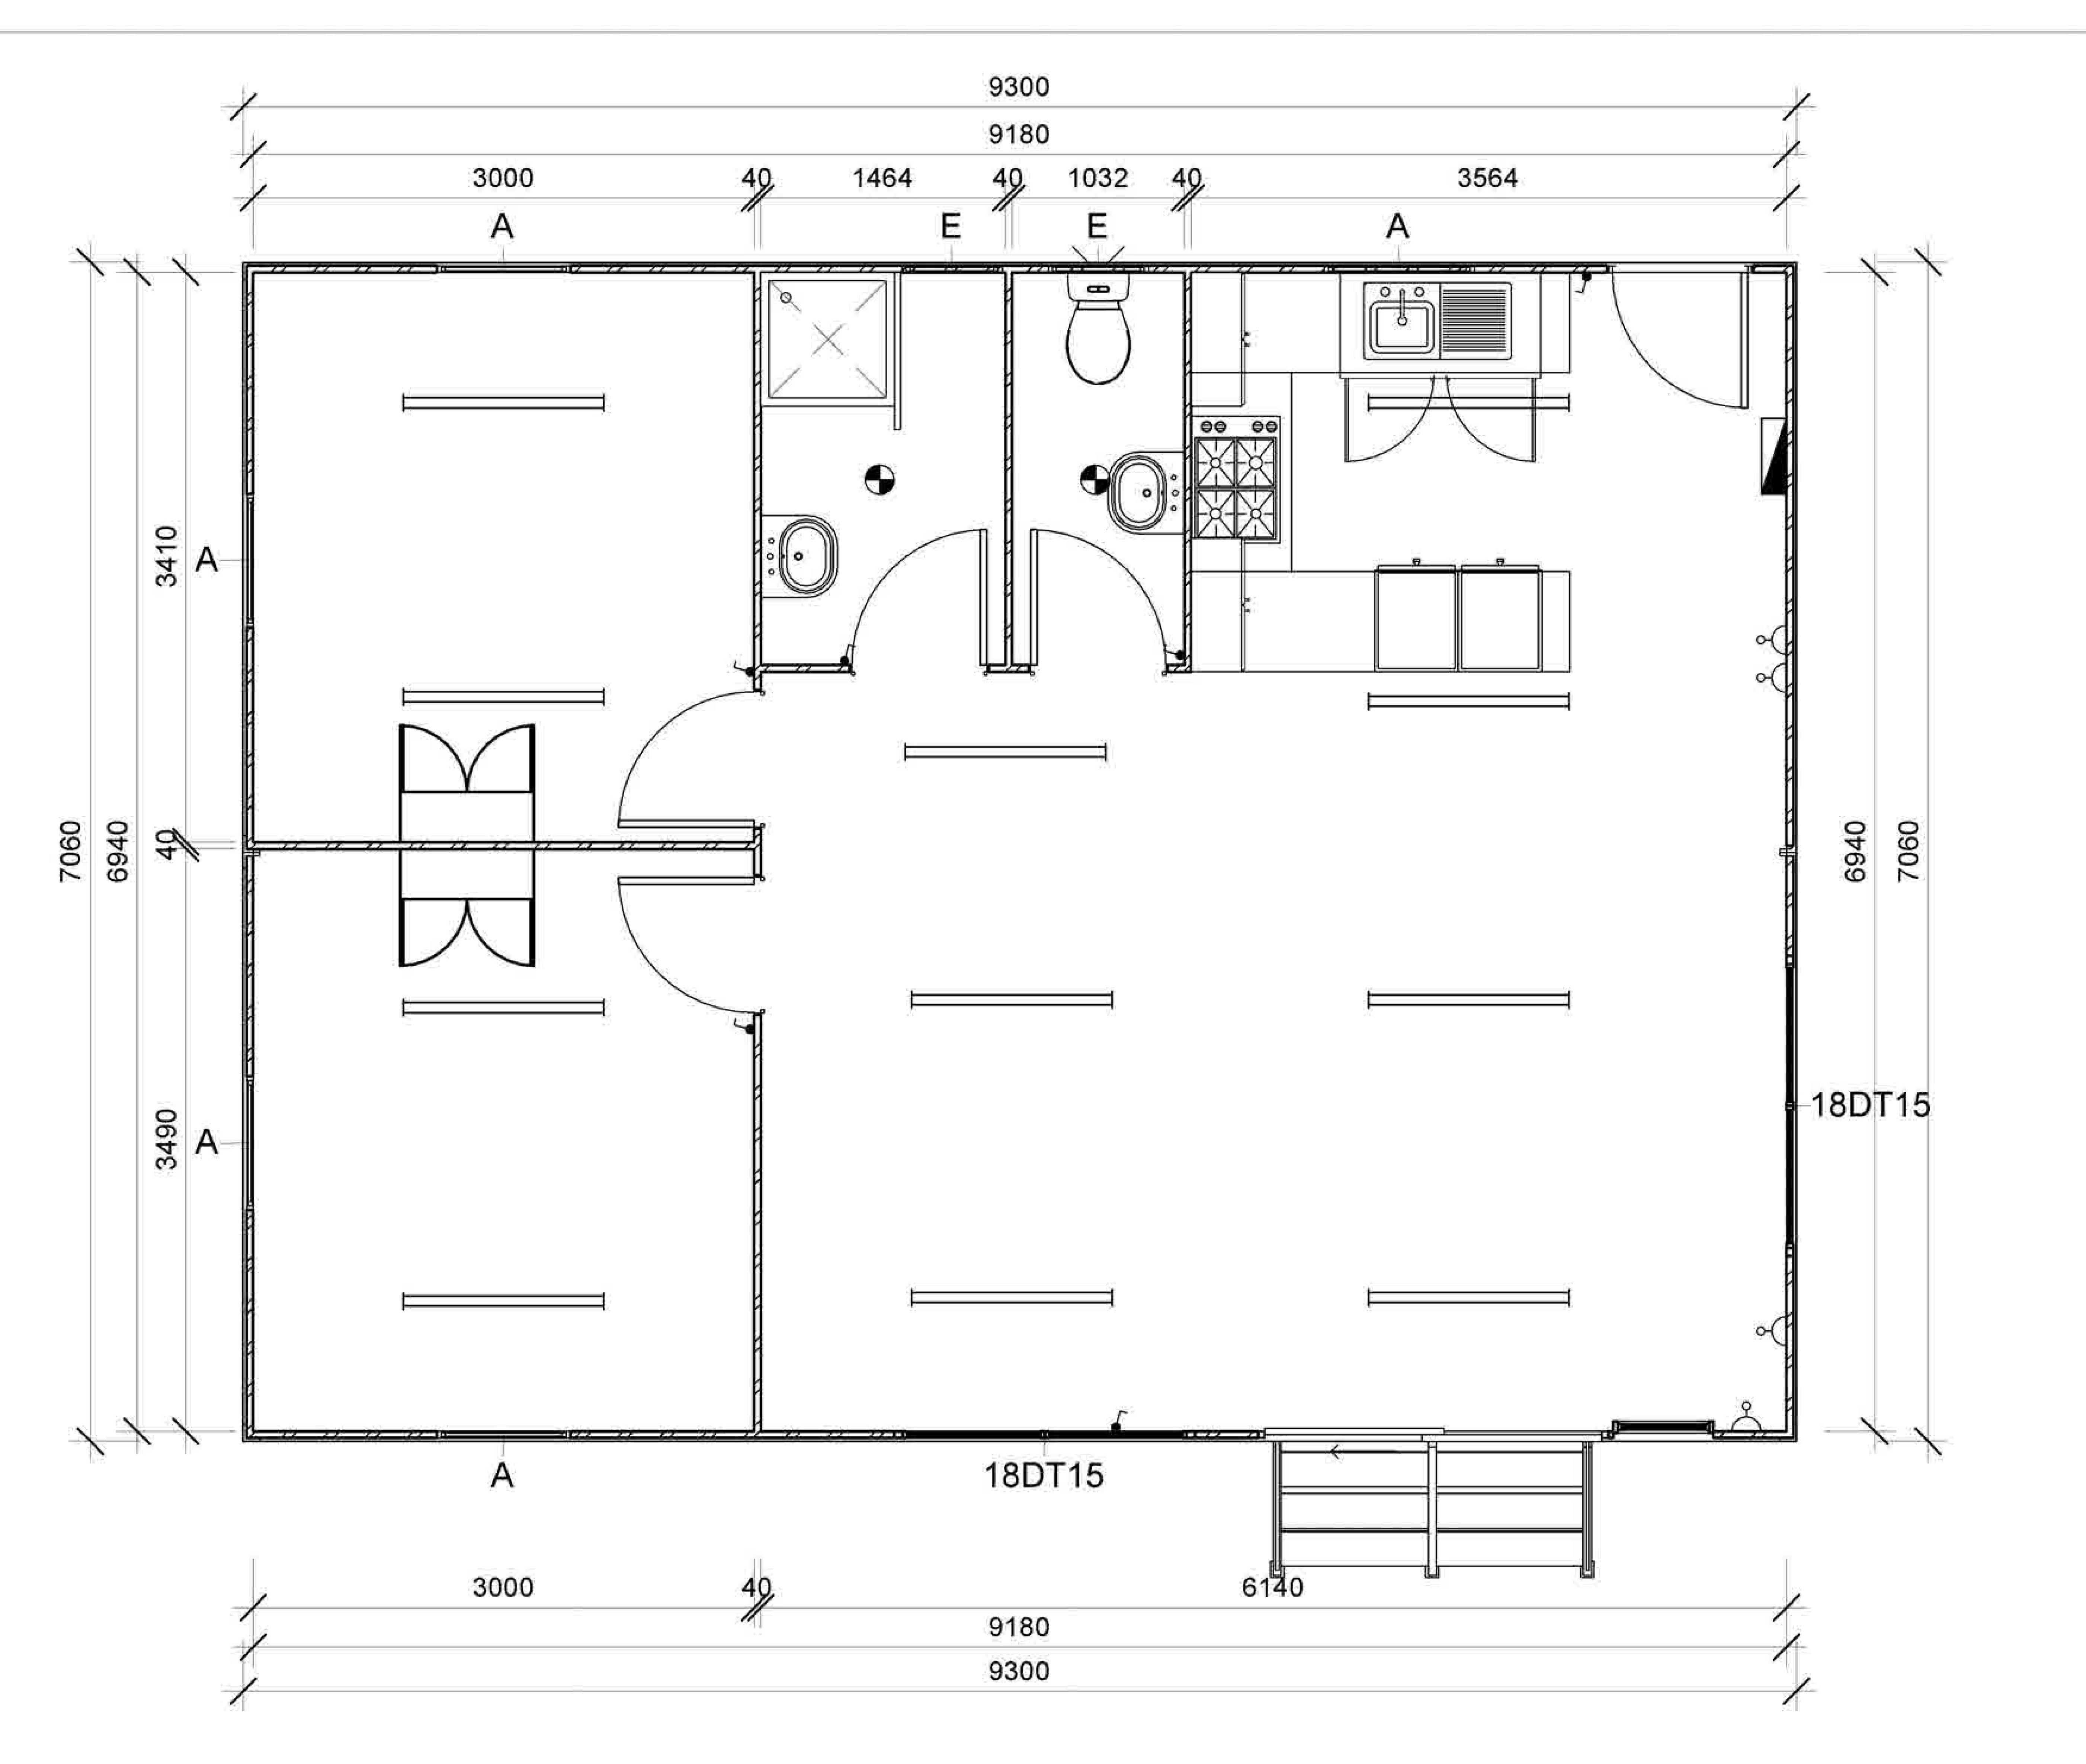

Floor Plan

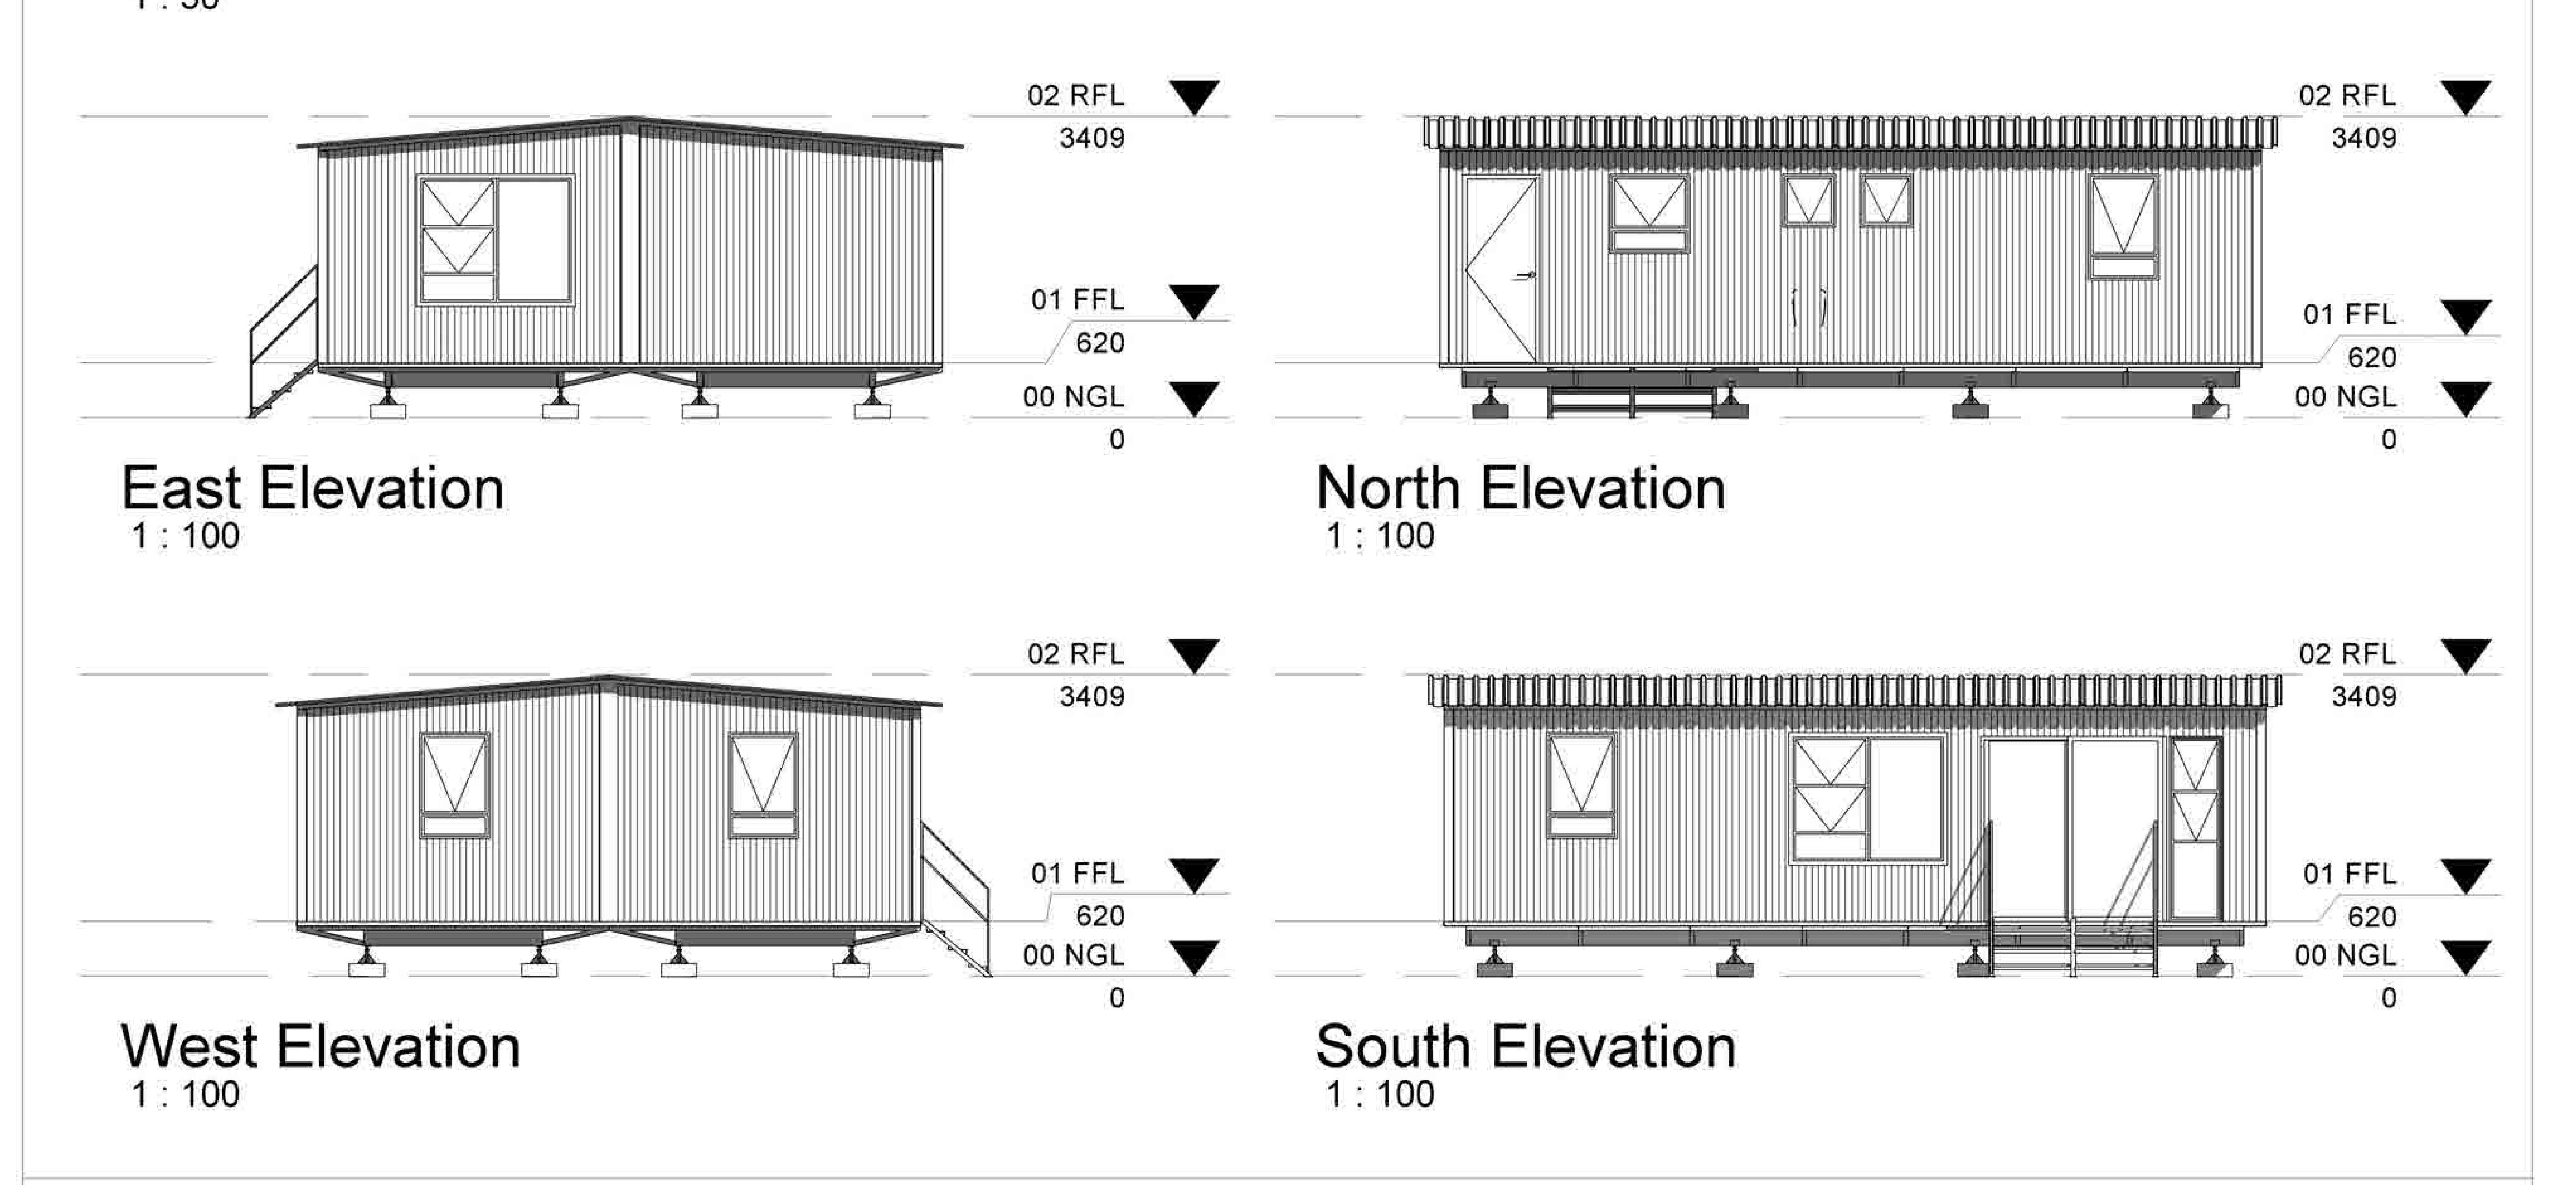




South Africa +27 11 794 1340

Botswana +267 391 3537

Zambia +260 96 034 9463

Email: sales@speedspace.co.za


Website: www.speedspace.co.za

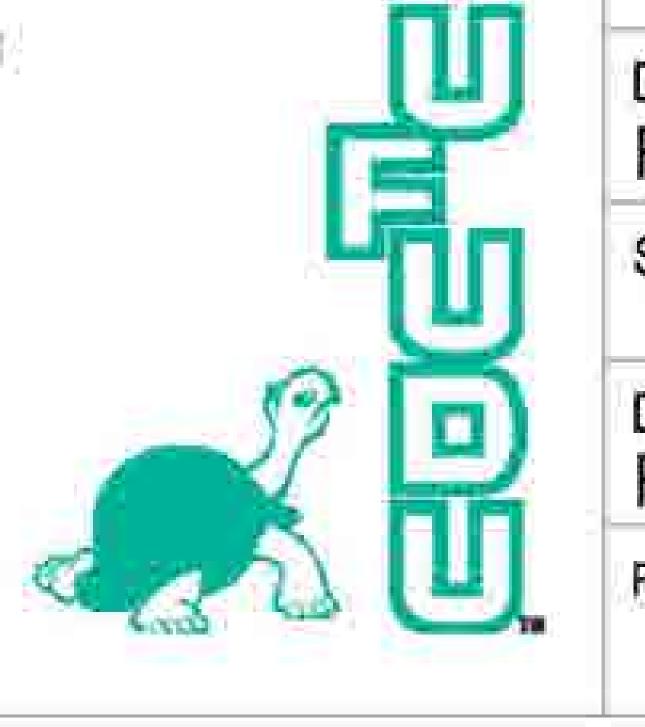

Drawing Information	Project Information
Prawing Description: Residential Unit	Client Name:
Scale:	Project Address:
Orawing Number: R335	
Revision Number:	Drawn By:

FOR INFORMATION ONLY Date:

This drawing is the property of speed space. The infomation contained herein is proprietary and confidential. This is a controlled drawing & unauthorized copying is not permissible 06/07/2016 10:43:57 AM

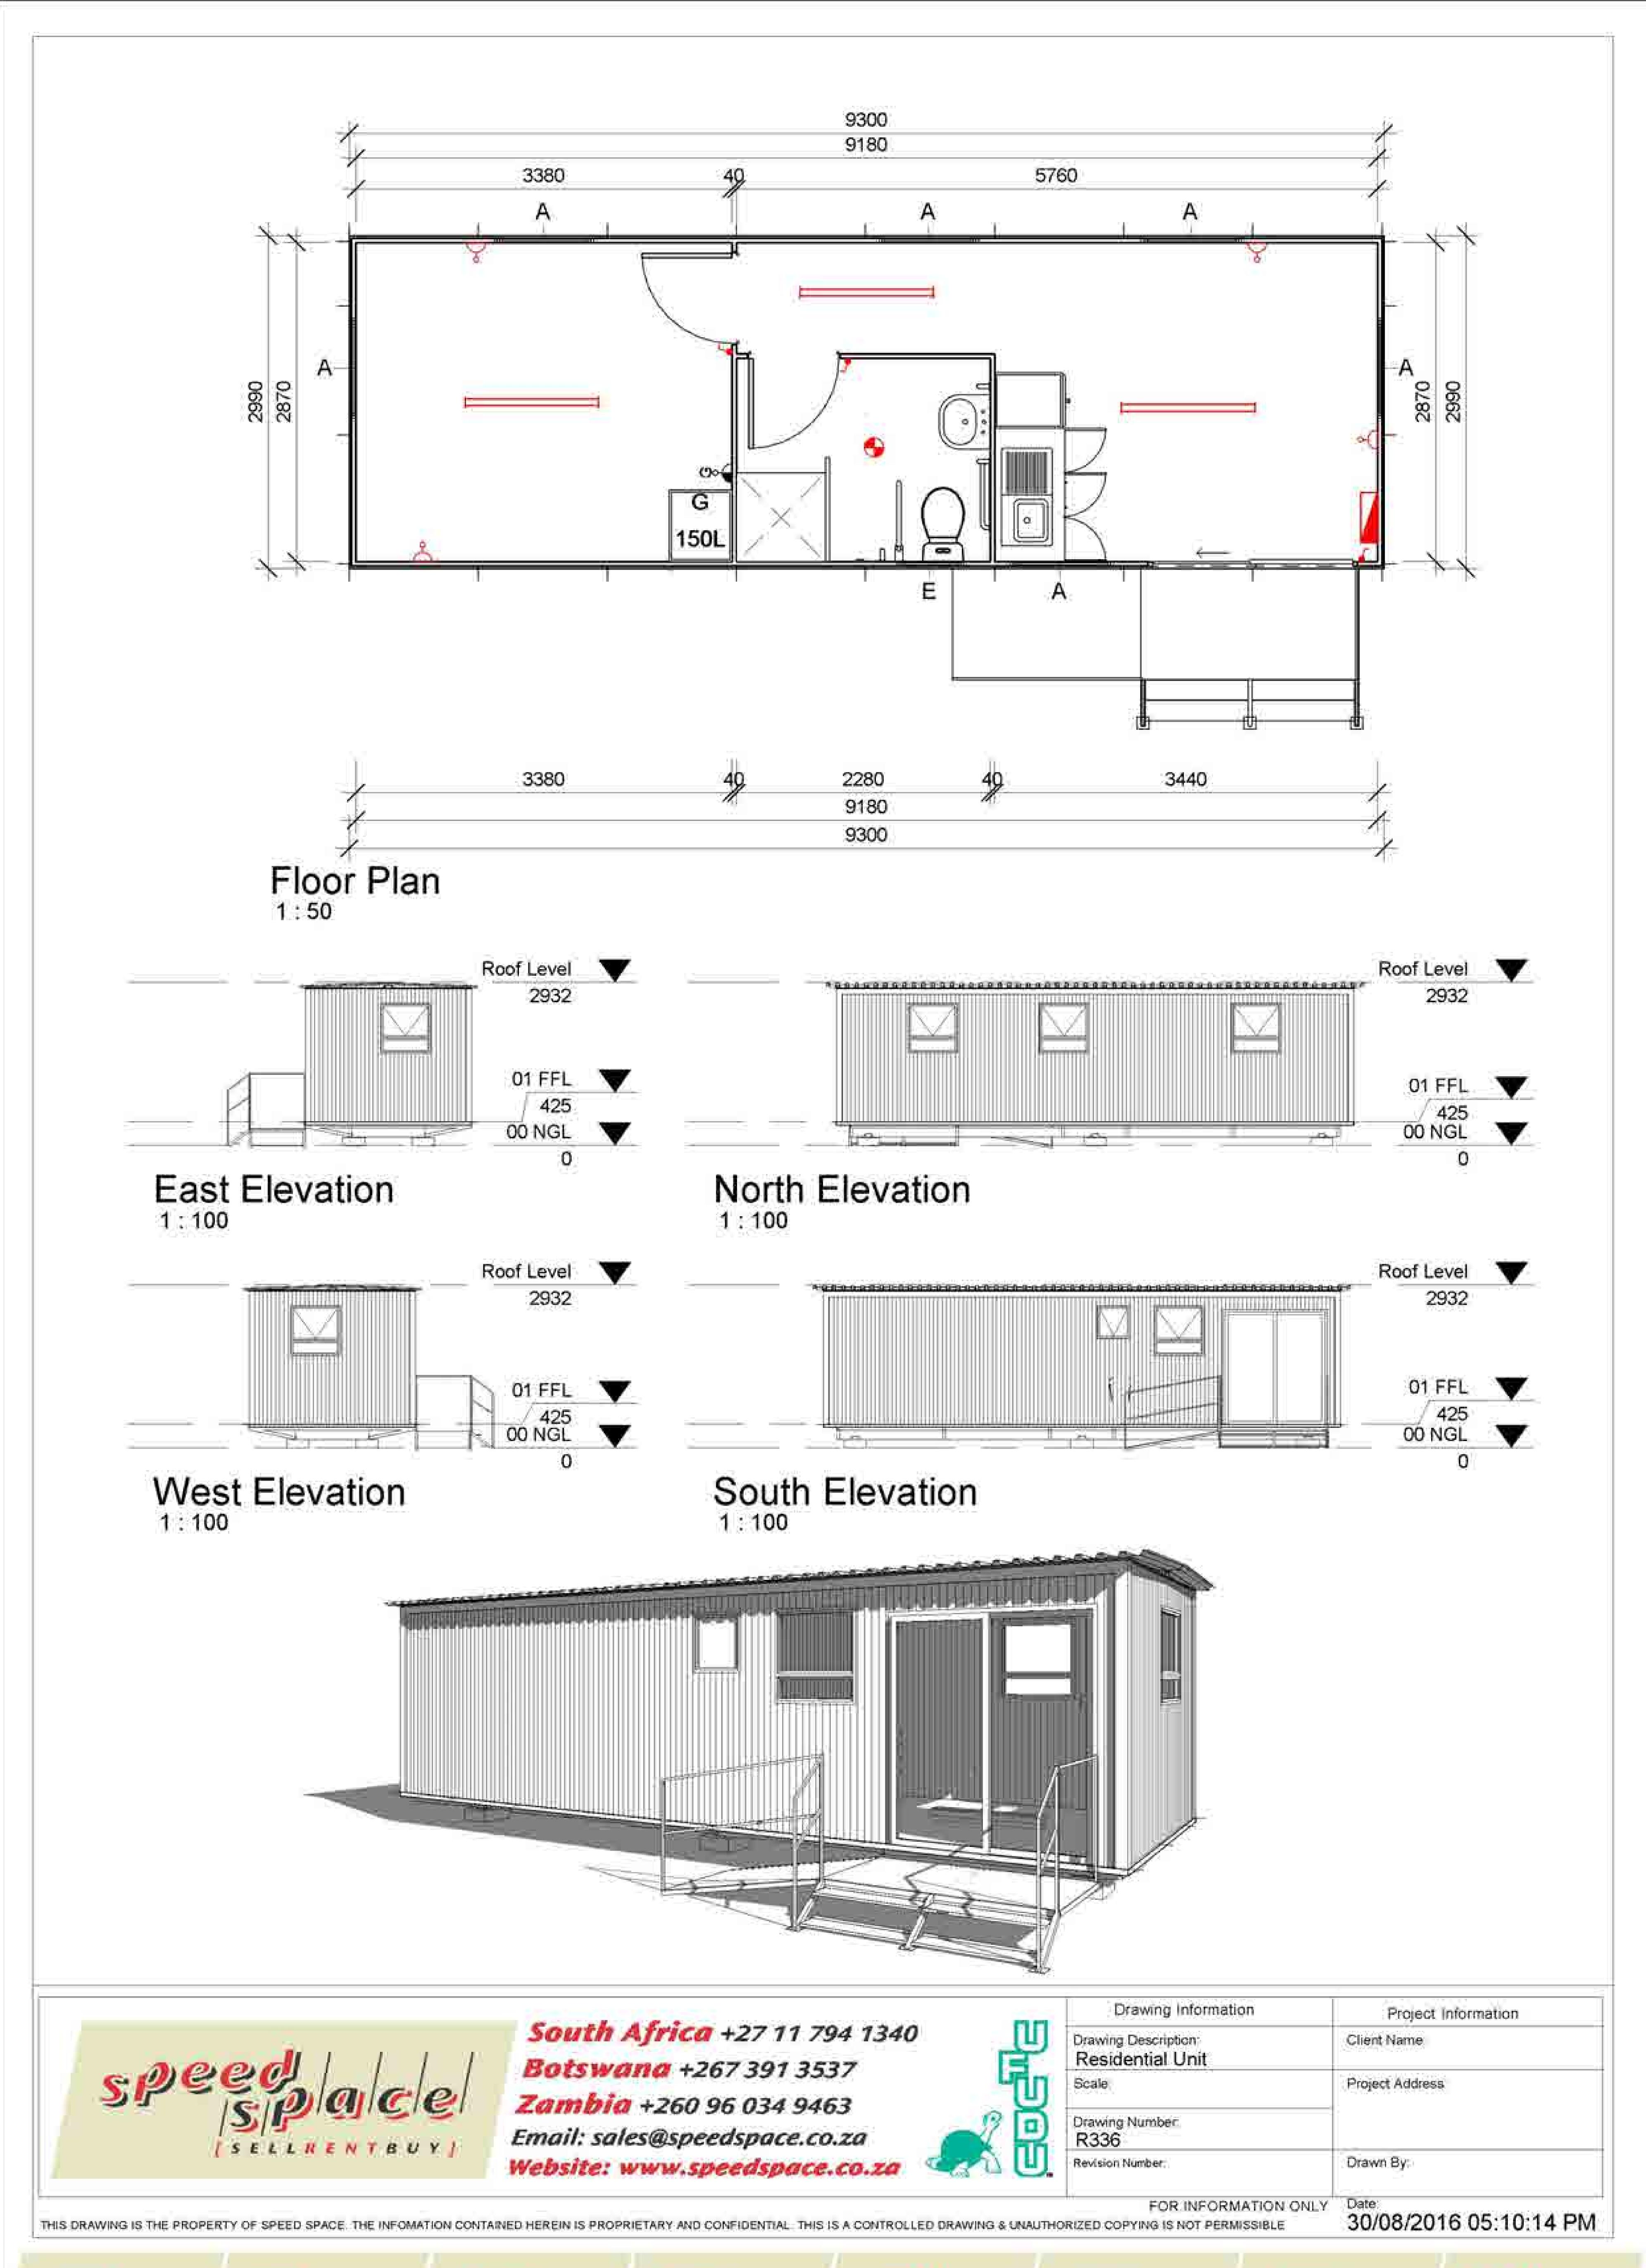

specklowk!

speed ffice

speed Res


speed leep


200660

speed pan

26556 1000


enfrenelle ca bien

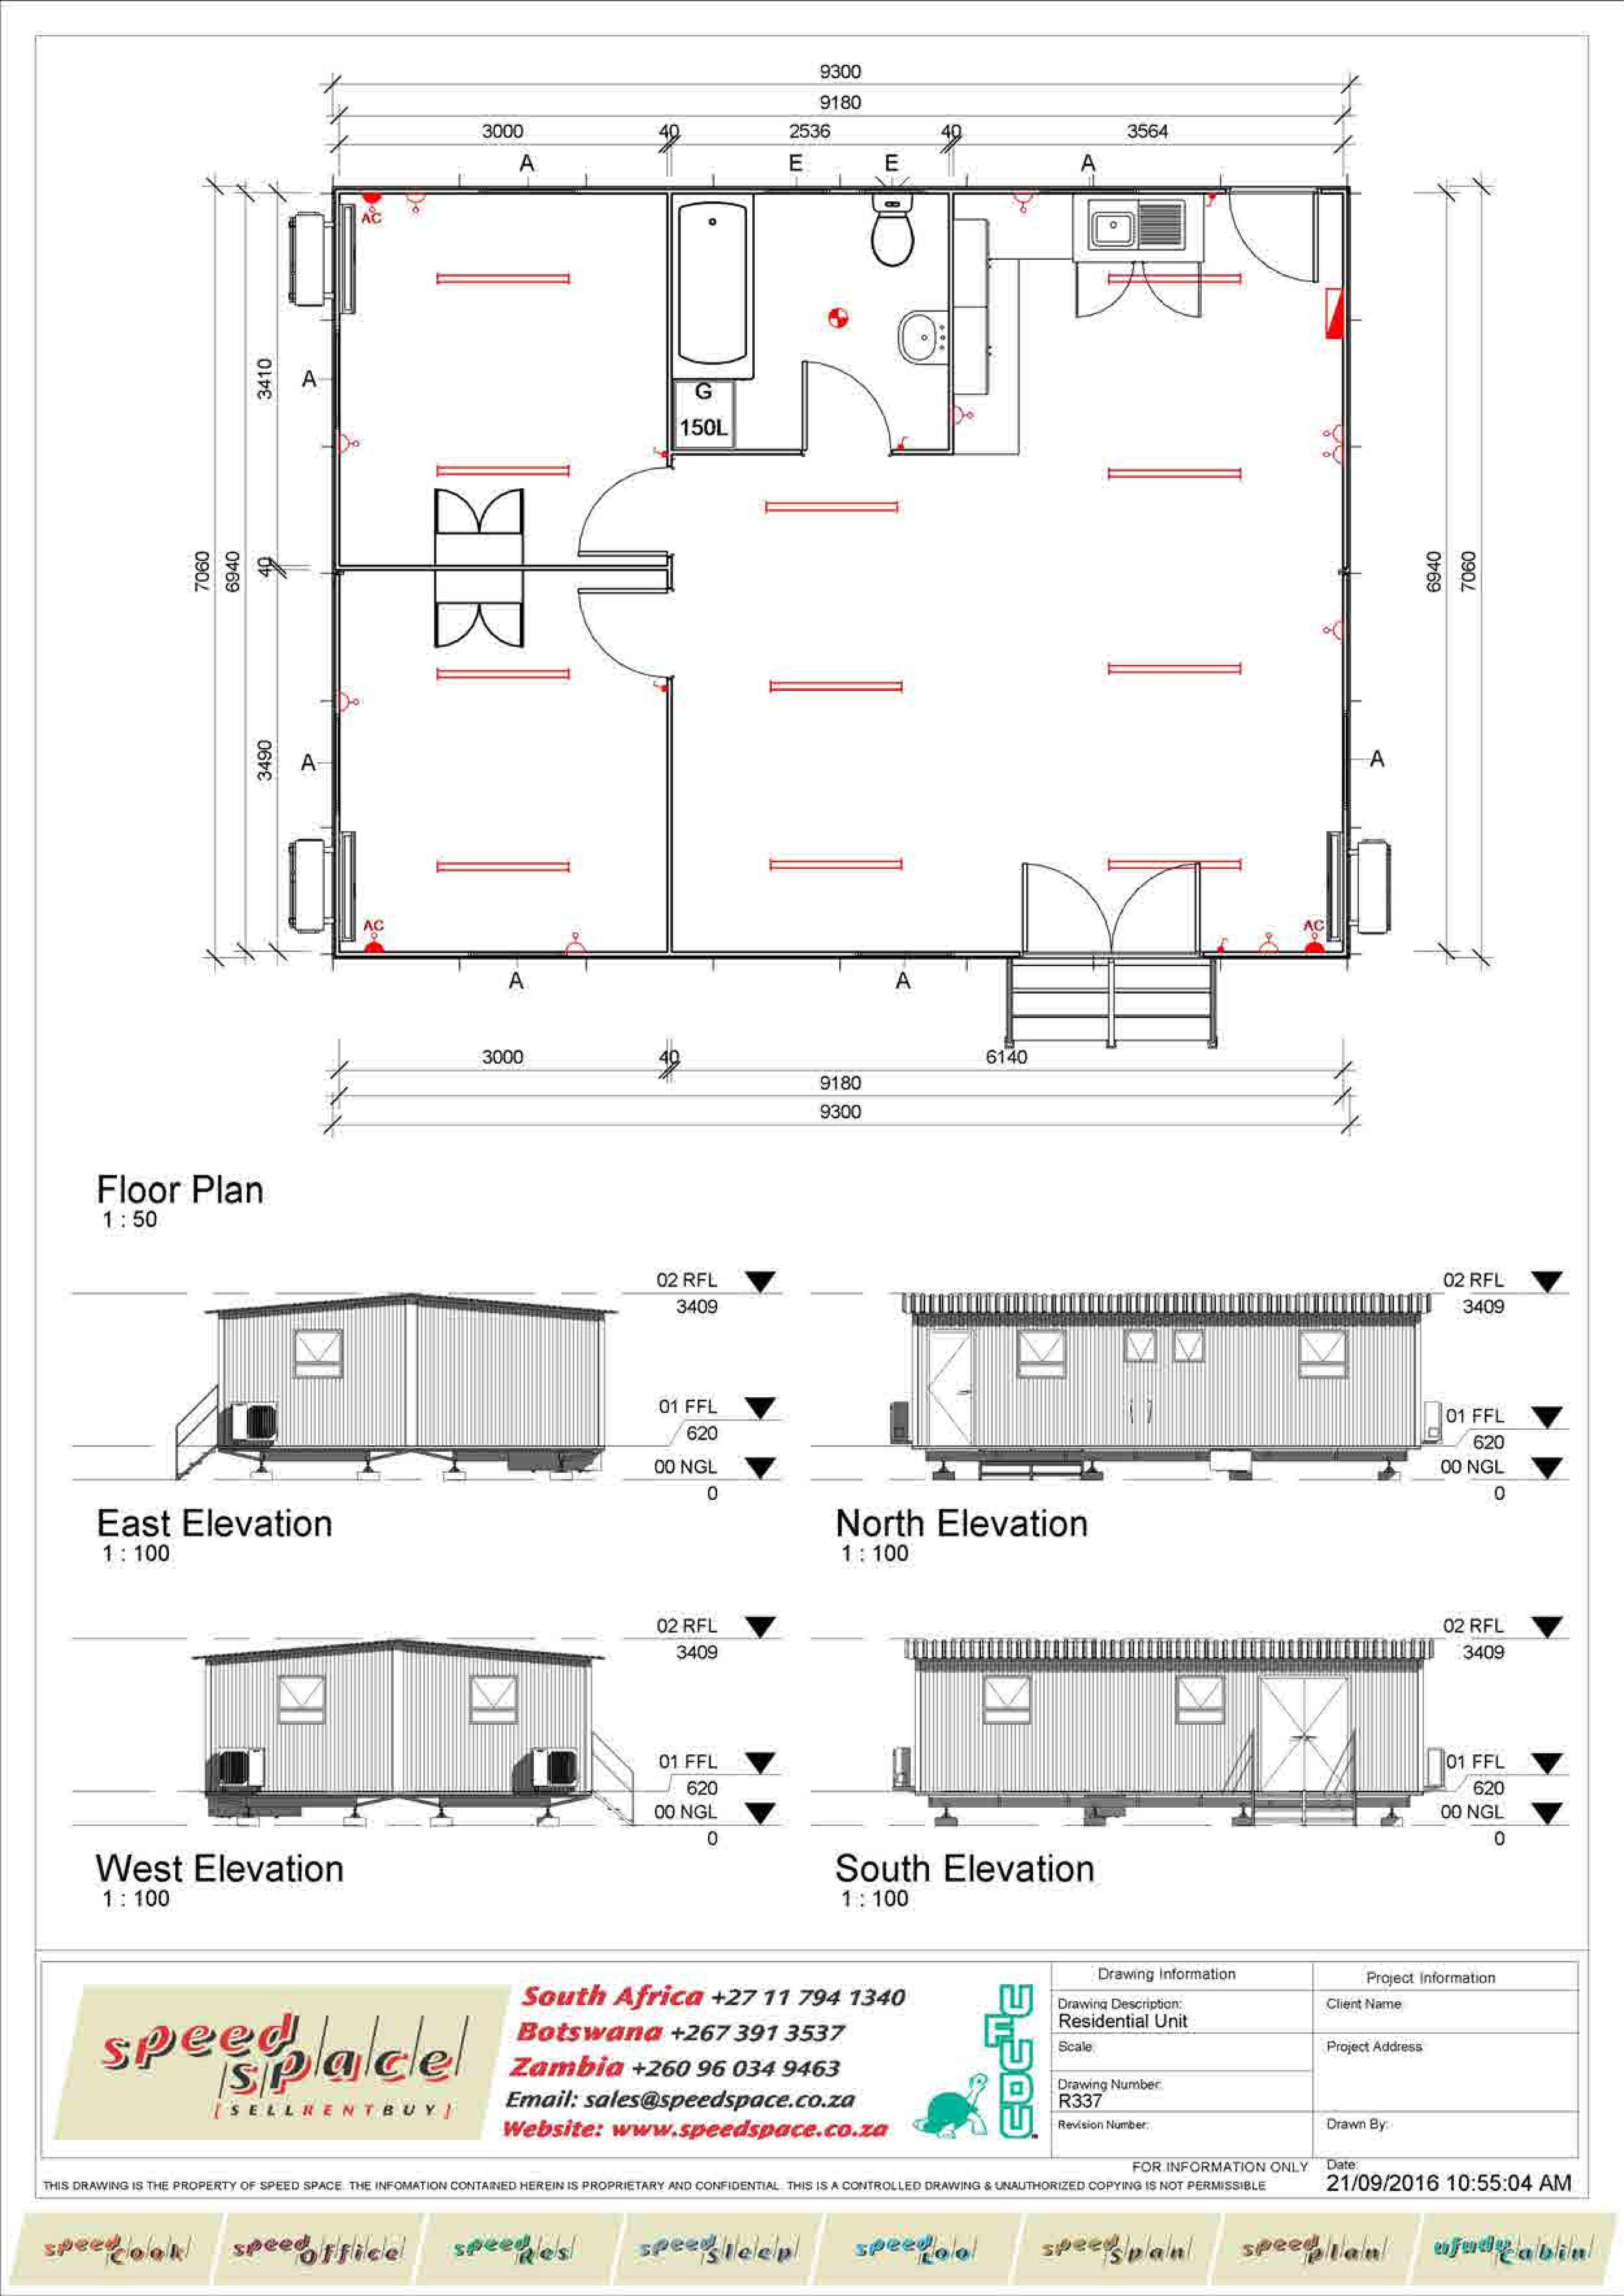

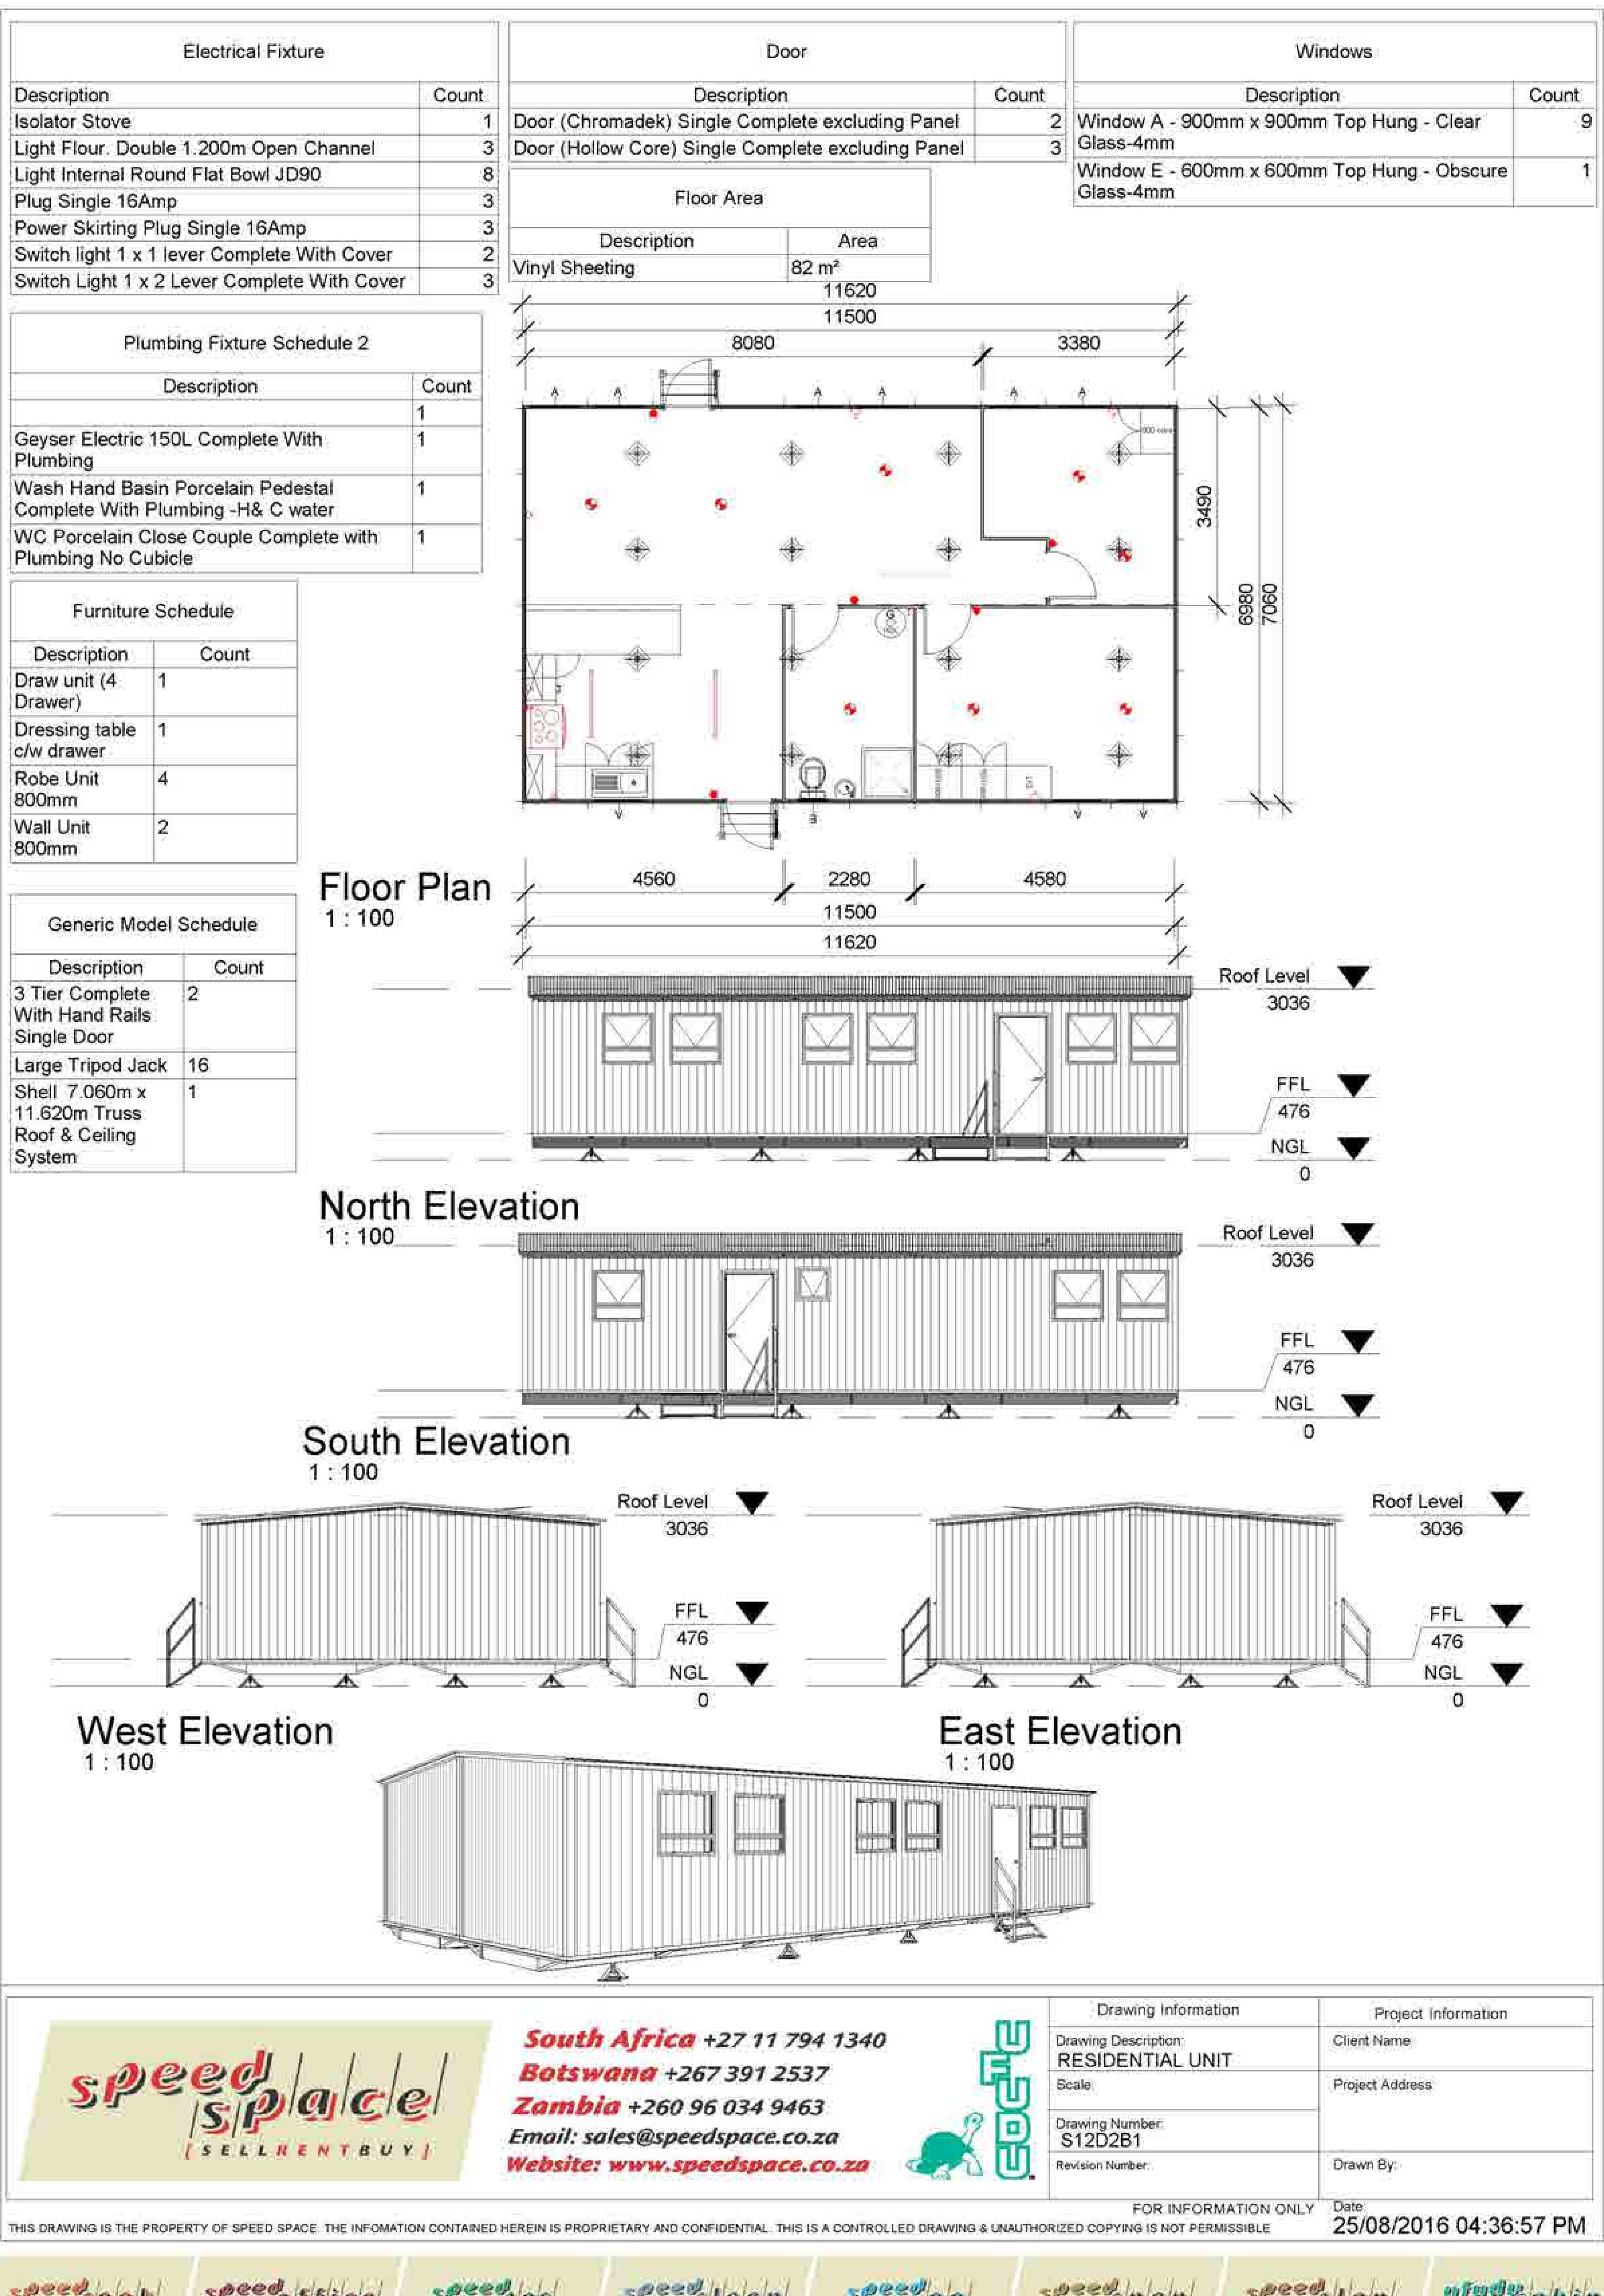

speed sleep

enfrenelle en la le ce

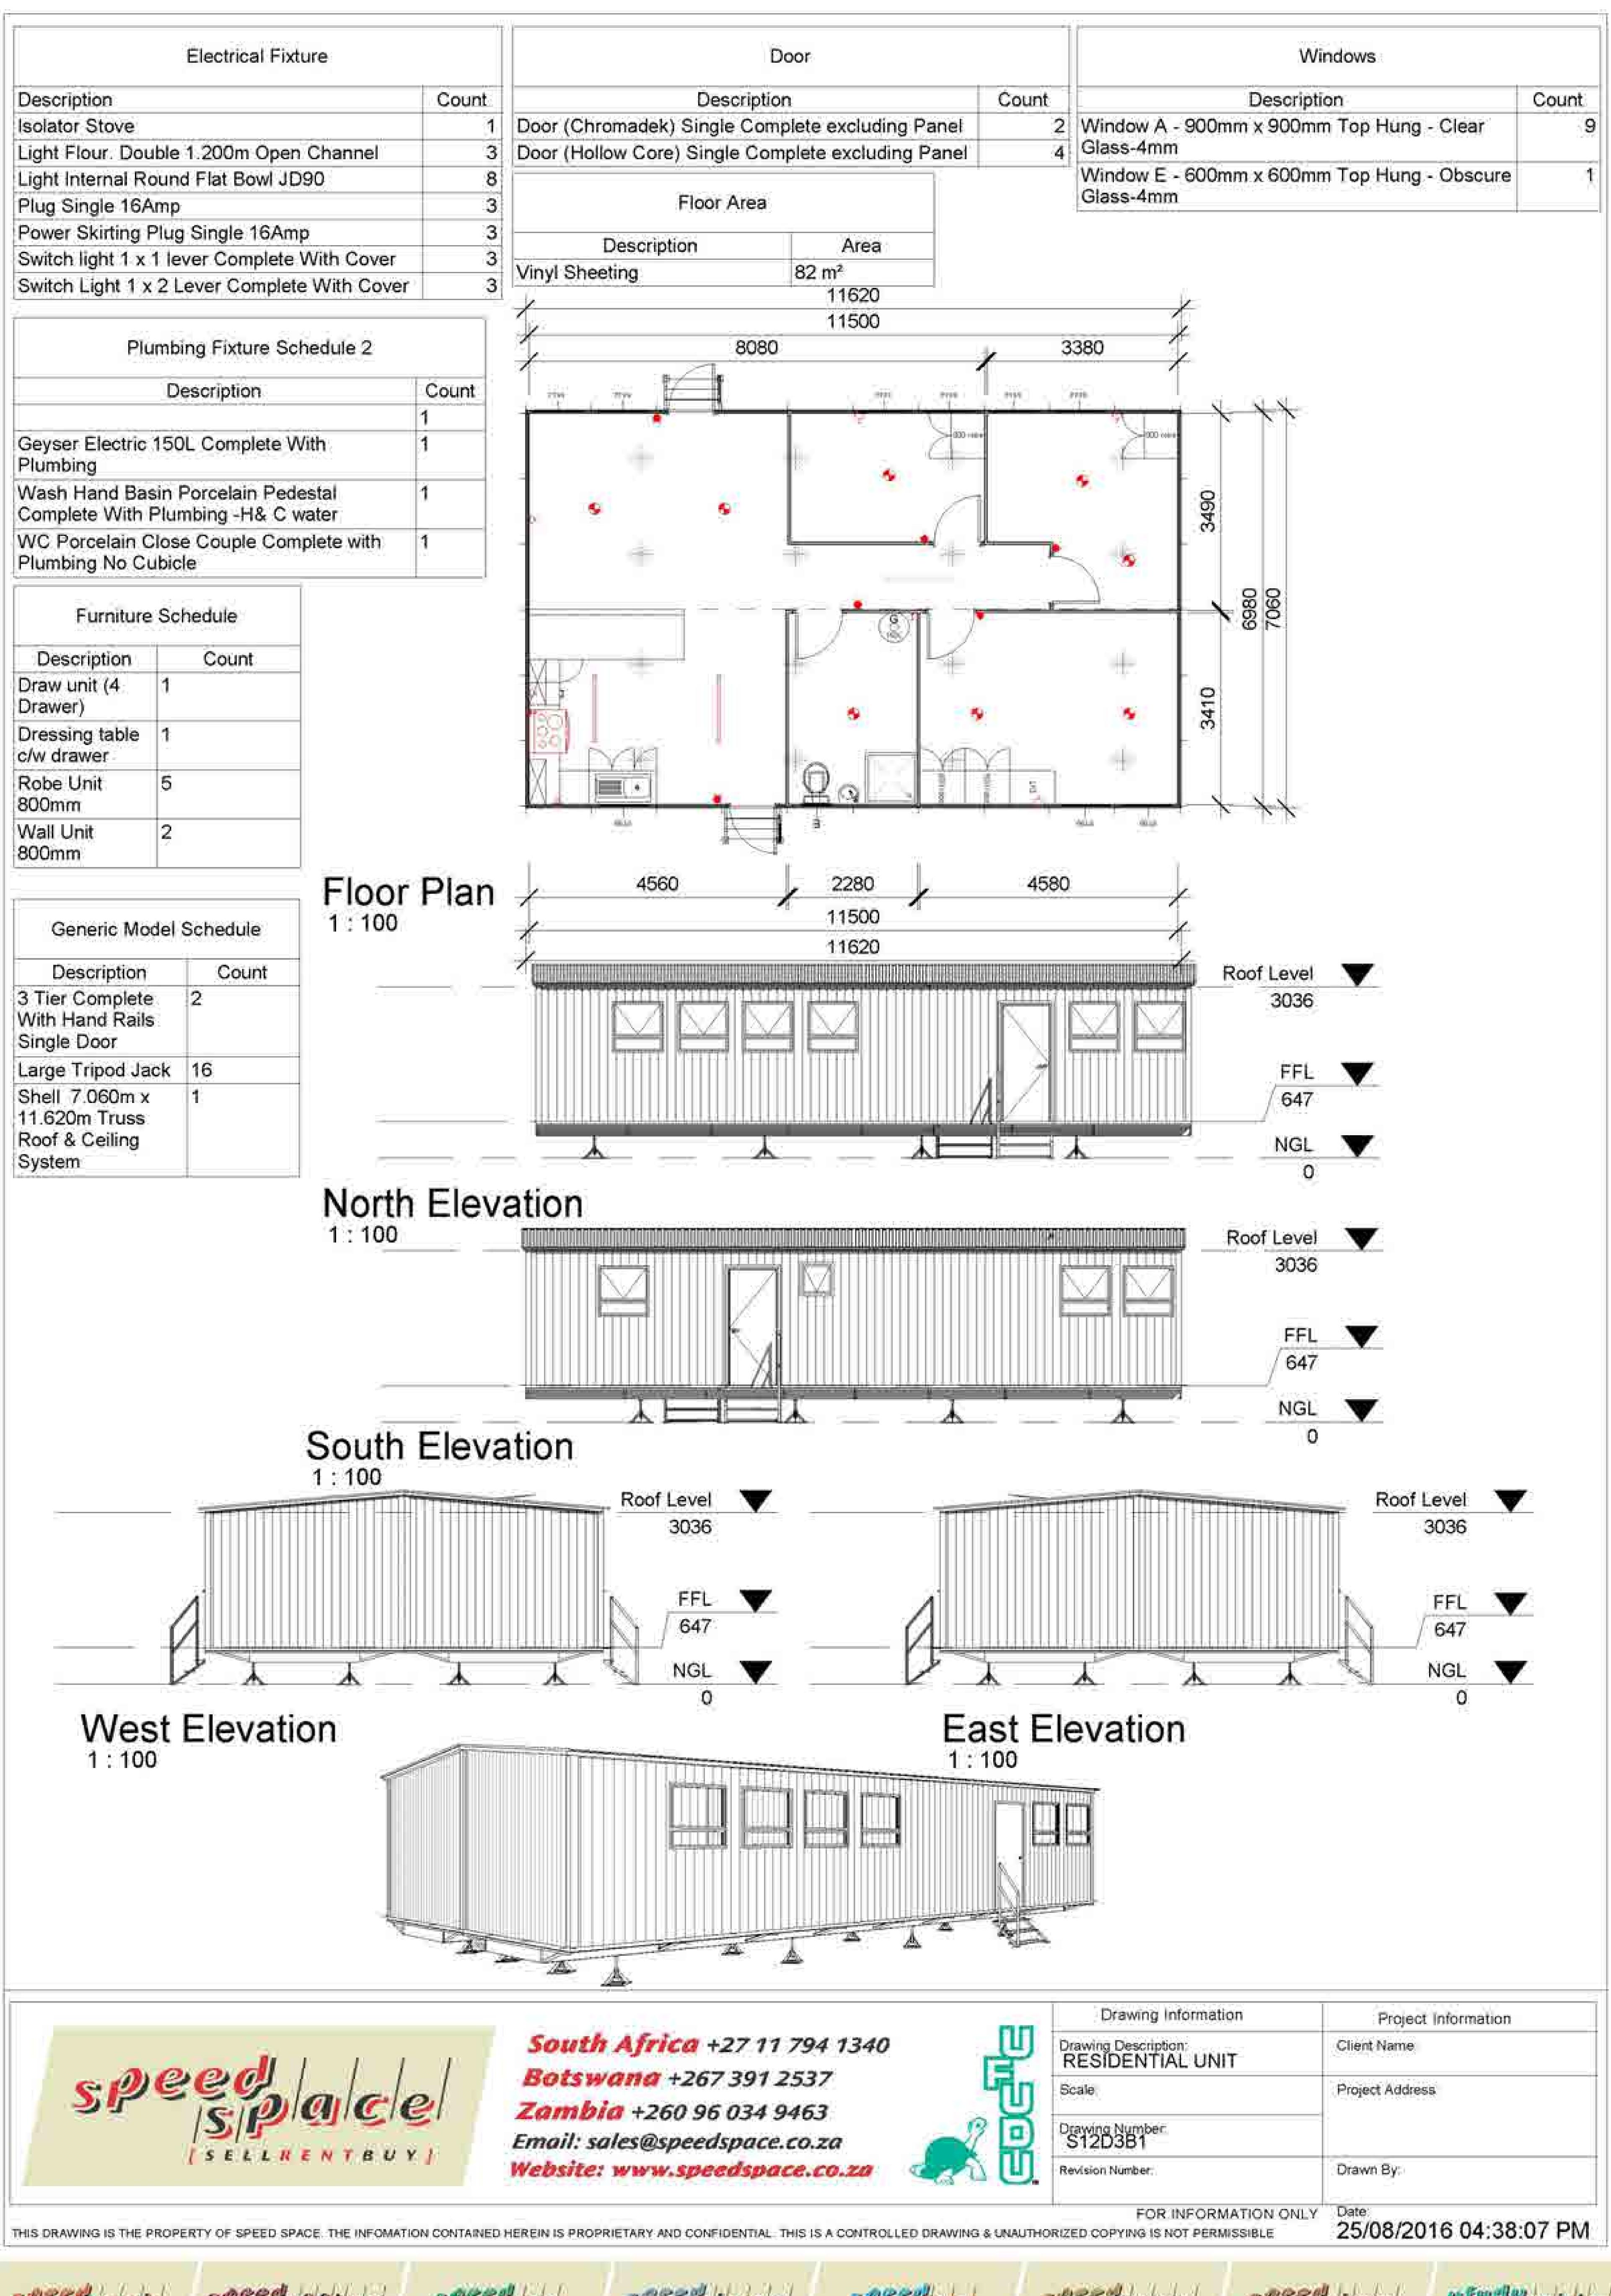

Sheer Cook

peed ffice

SPERES

speed leep

20000

30000 15/10/10/11

26666 1000

enfrenell & co be en

Electrical Fixture	
Description	Count
Distribution Board 12 Way	1
Isolator Stove	1
Light Flour. Double 1.200m Open Channel	1
Light Internal Round Flat Bowl JD90	5
Plug Double 16Amp	2
Plug Single 16Amp	2
Switch light 1 x 1 lever Complete With Cover	1
Switch Light 1 x 2 Lever Complete With Cover	1

Description	Count
Geyser Electric 250L Complete With Plumbing	1
Shower x 1 Complete With Plumbing/Curtain & Partition	4
Sink 1.200m Single Bowl Complete With Cupboards & Plumbing	1
Wash Hand Basin Porcelain Pedestal Complete With Plumbing -H& C water	1
WC Porcelain Close Couple Complete with Plumbing No Cubicle	1


Description	Count
Ooor (Chromadek) Single Complete excluding Panel	2
Door (Hollow Core) Single Complete excluding Panel	3

Furniture So	nedule	
Description	Count	Worktop Length
Draw unit (4 Drawer)	1	
Dressing table c/w drawer	2	
Robe Unit 800mm	2	
Wall Unit 400mm	1	
Wall Unit 800mm	1	
Work Top	2	


Windows	
Description	Count
Window A - 900mm x 900mm Top Hung - Clear Glass-4mm	4
Window E - 600mm x 600mm Top Hung - Obscure Glass-4mm	

Description	Count
1 Tier Complete With Hand Rails Single Door	2
Screw-in Jack	8
Shell 2.99m x 11.62m	1


Floor Area	a
Description	Area
Vinyl Sheeting	35 m²

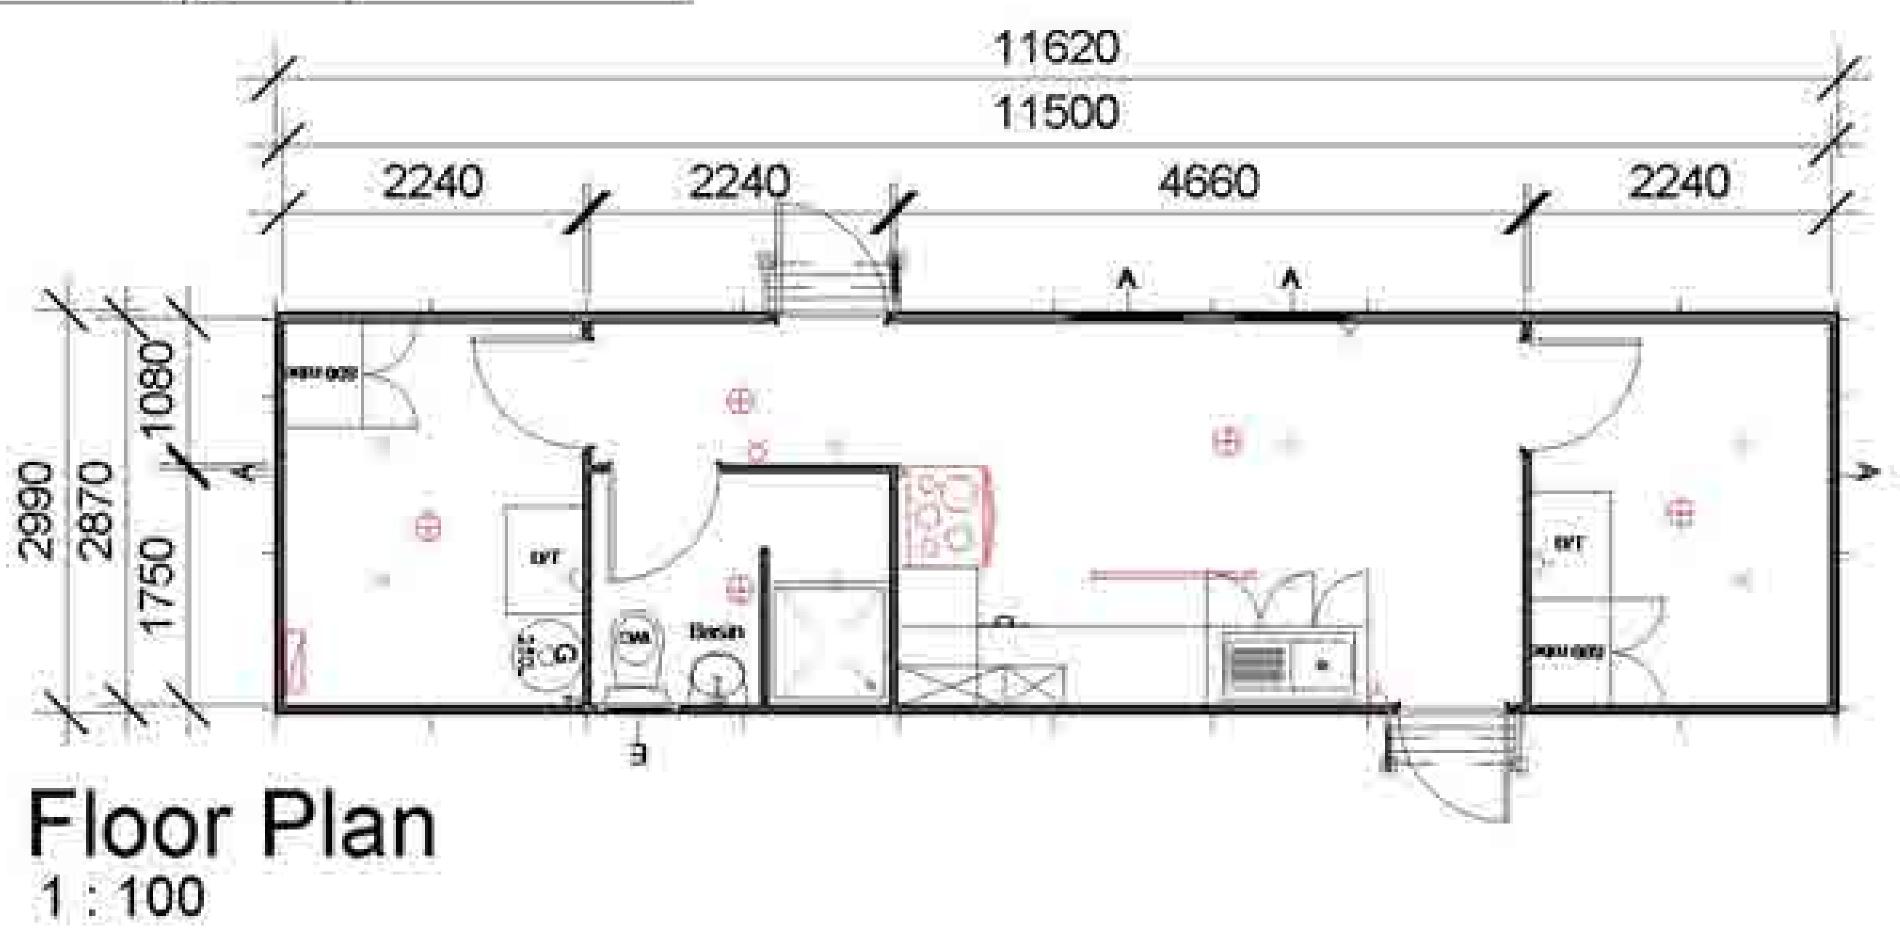



1:100

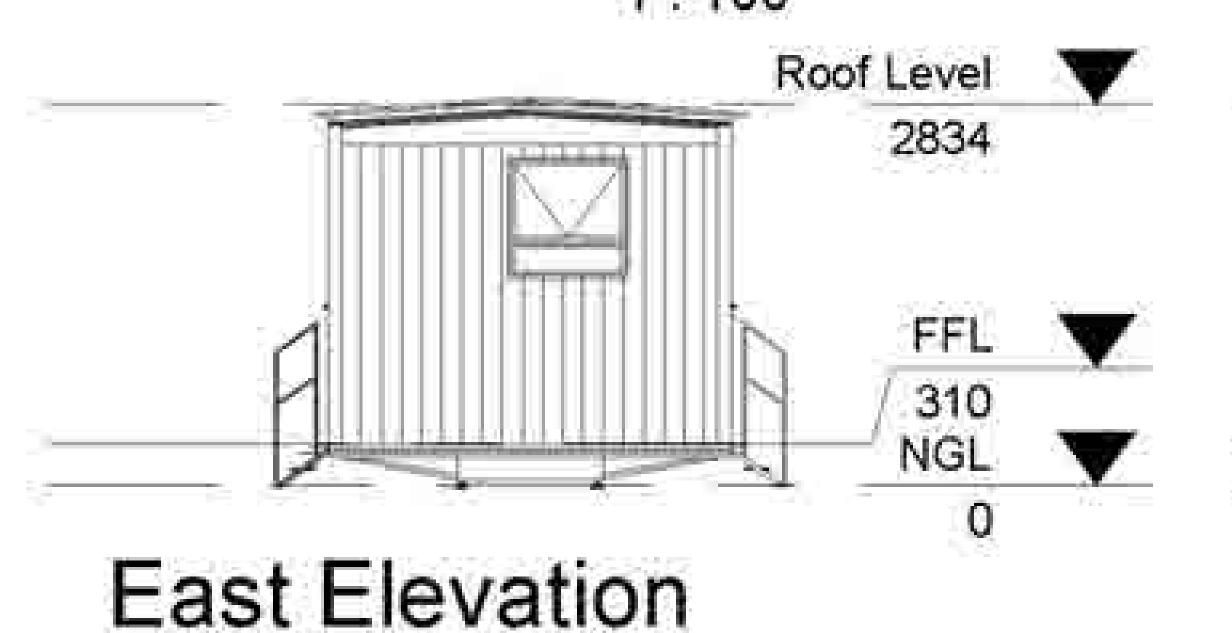


1:100

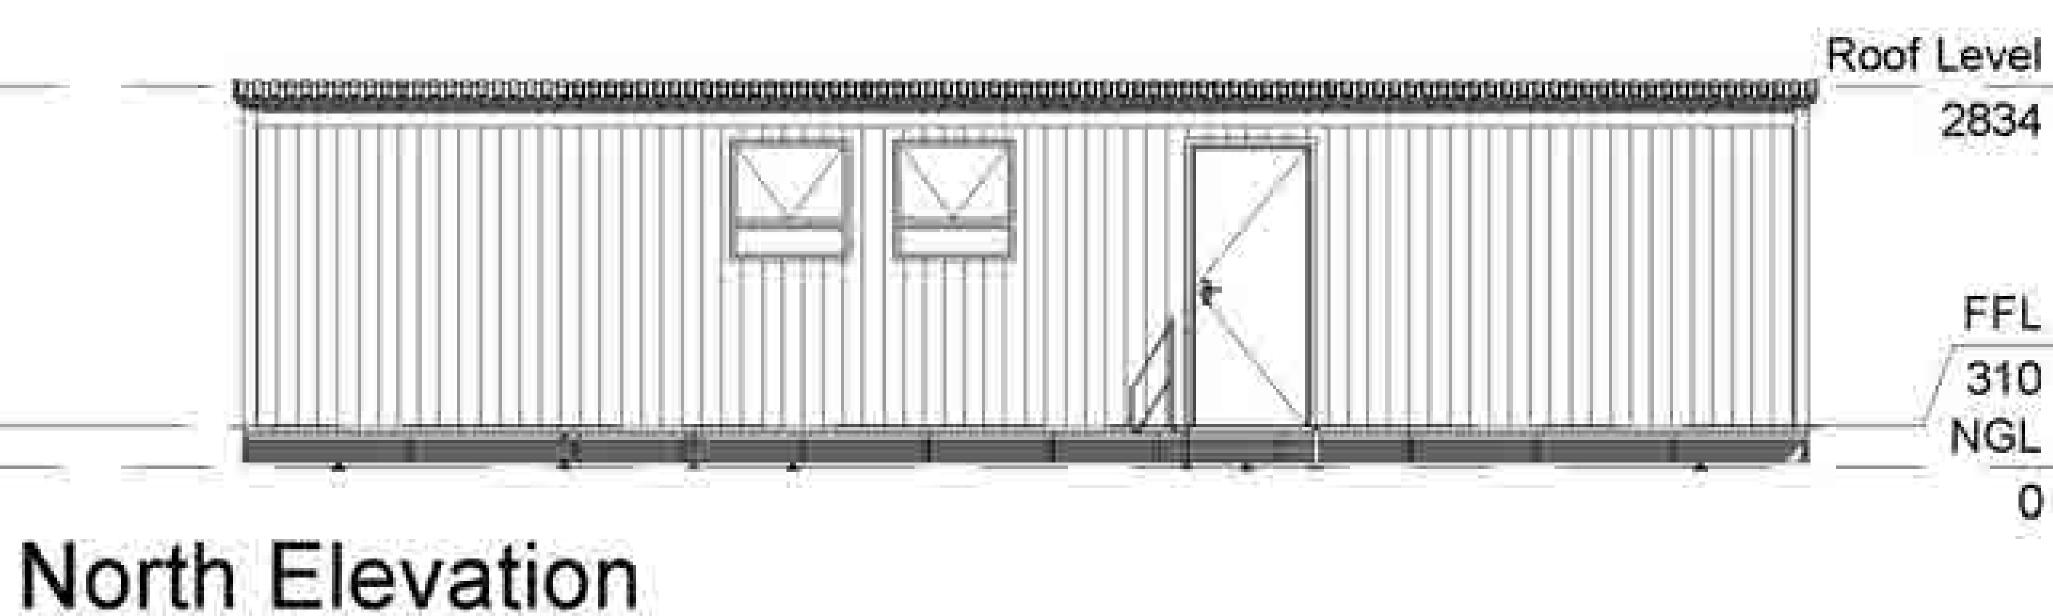

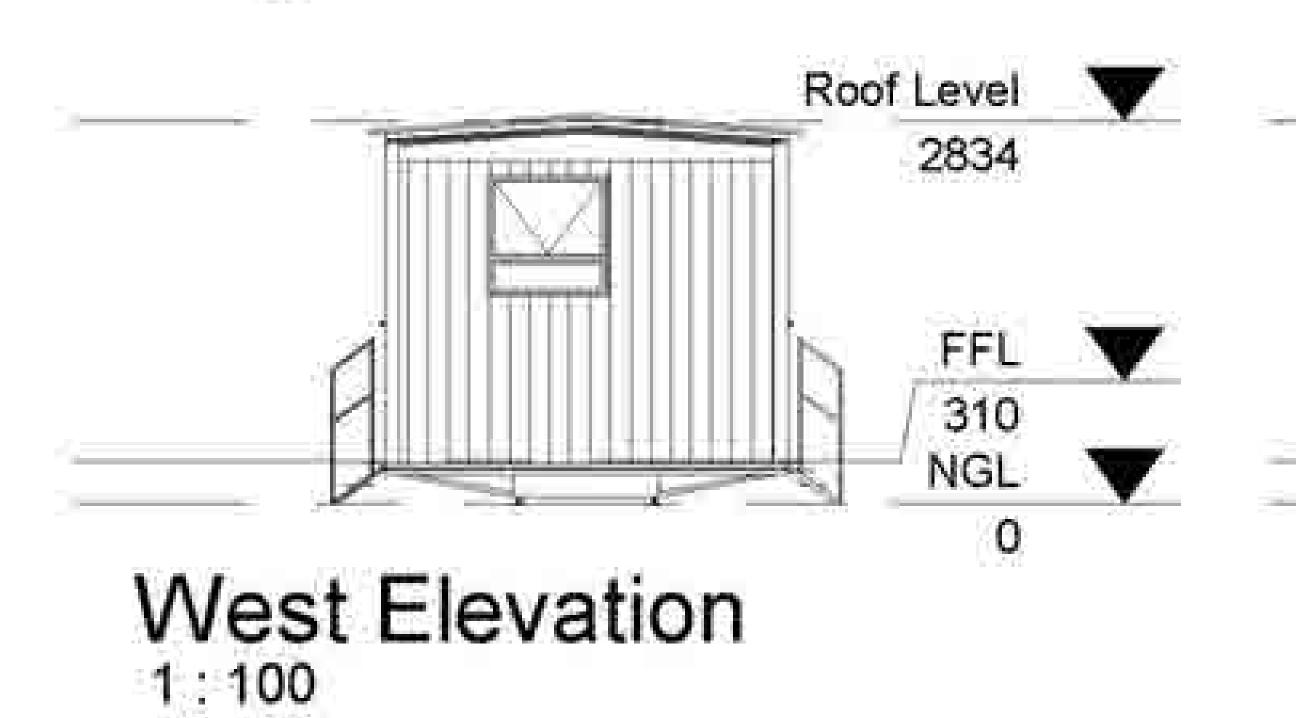


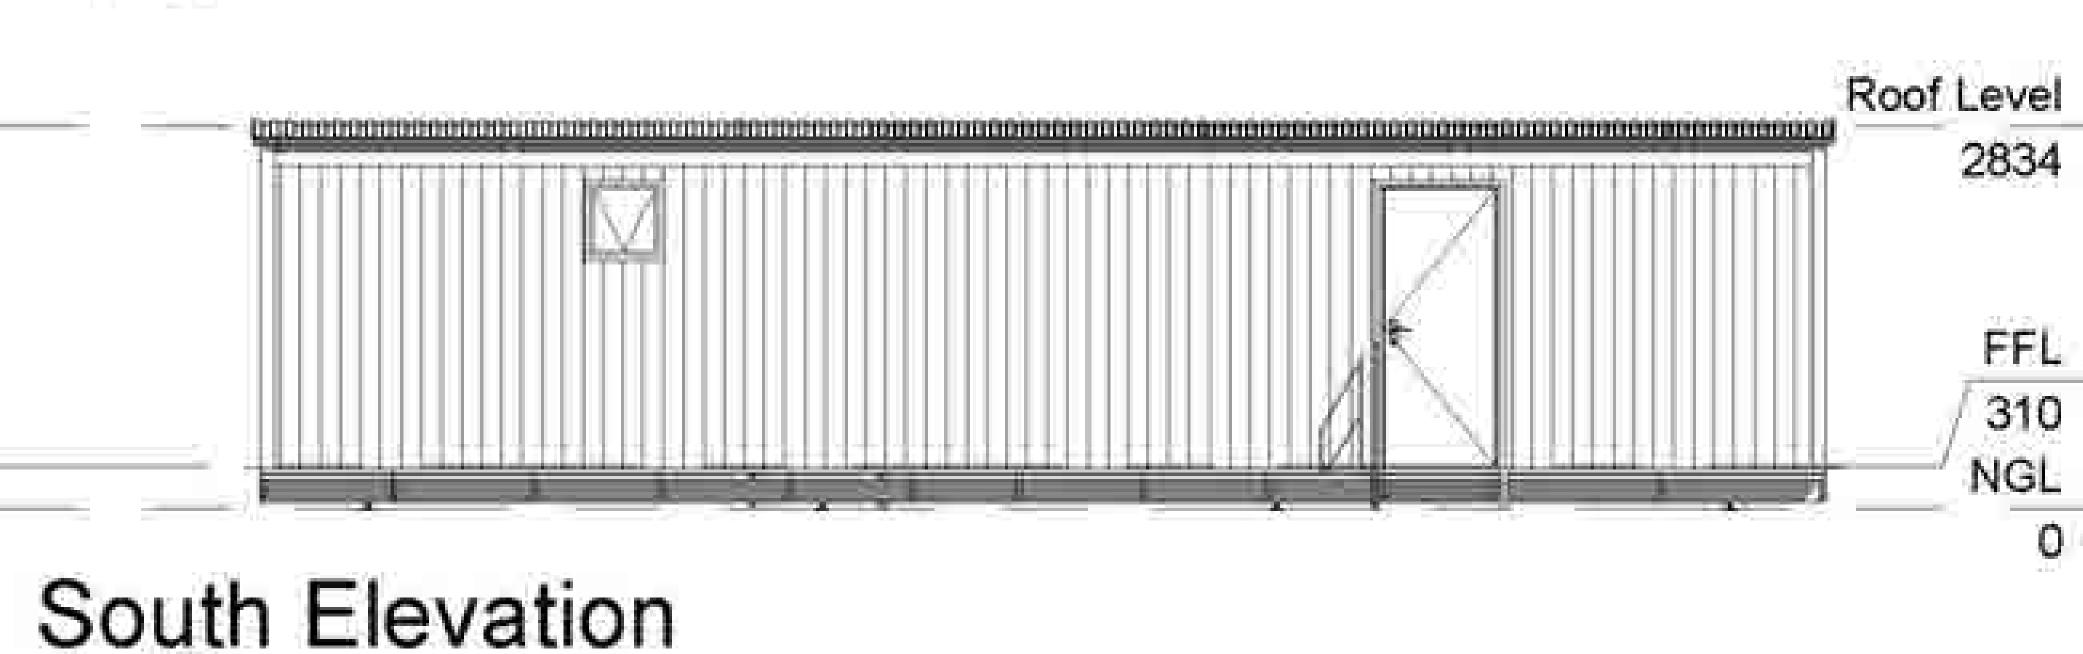

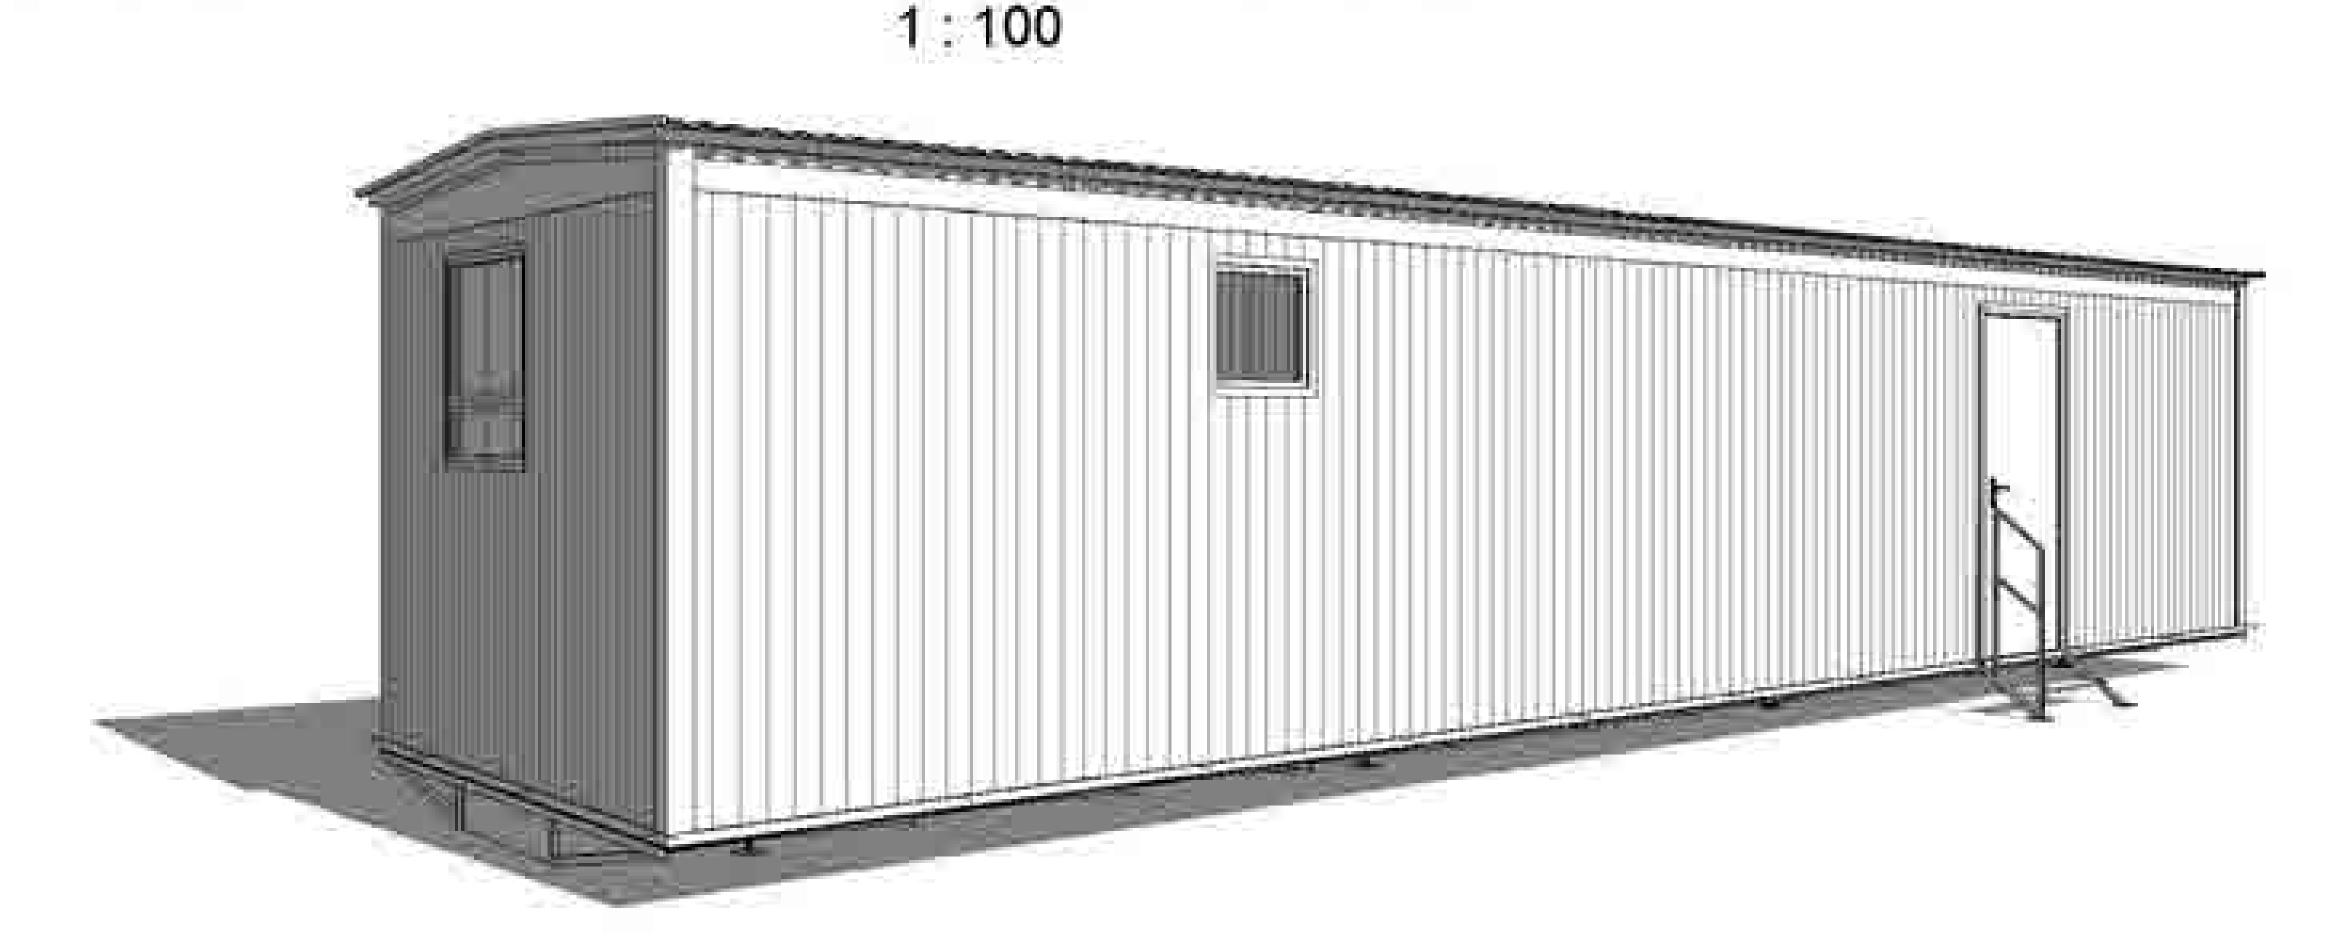



South Africa +27 11 794 1340 Botswana +267 391 2537 Zambia +260 96 034 9463 Email: sales@speedspace.co.za Website: www.speedspace.co.za

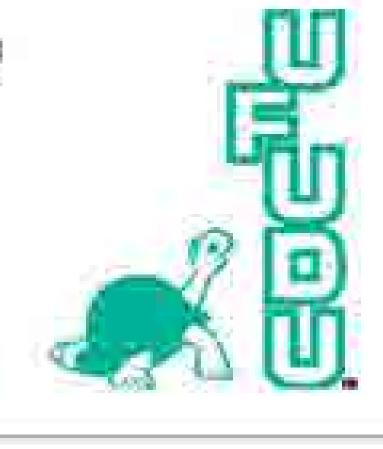

Drawing Information	Project Information
Drawing Description: RESIDENTIAL UNIT	Client Name
Scale	Project Address
Drawing Number S12S2B1	
Revision Number	Drawn By:

FOR INFORMATION ONLY

25/08/2016 04:42:41 PM

Speed plan

enfiguell & calla le tr



Description	Count
	1
Geyser Electric 250L Complete With Plumbing	1
Wash Hand Basin Porcelain Pedestal Complete With Plumbing -H& C water	1
WC Porcelain Close Couple Complete with Plumbing No Cubicle	1

Description	Count
3 Tier Complete With Hand Rails Single Door	2
Large Tripod Jack	20
Shell 7.060m x 15.100m Truss Roof & Ceiling System	1

Floor Plan


1:100


Description	Count	
Door (Chromadek) Single Complete excluding Panel	2	W
Door (Hollow Core) Single Complete excluding Panel	4	G


Furniture Schedule	
Description	Count
Draw unit (4 Drawer)	4
Dressing table c/w drawer	1
Robe Unit 800mm	5
Vall Unit 800mm	2


Windows	
Description	Count
Window A - 900mm x 900mm Top Hung - Clear Glass-4mm	1.1
Window E - 600mm x 600mm Top Hung - Obscure Glass-4mm	-1

Floor Area	
Description	Area
inyl Sheeting	107 m²

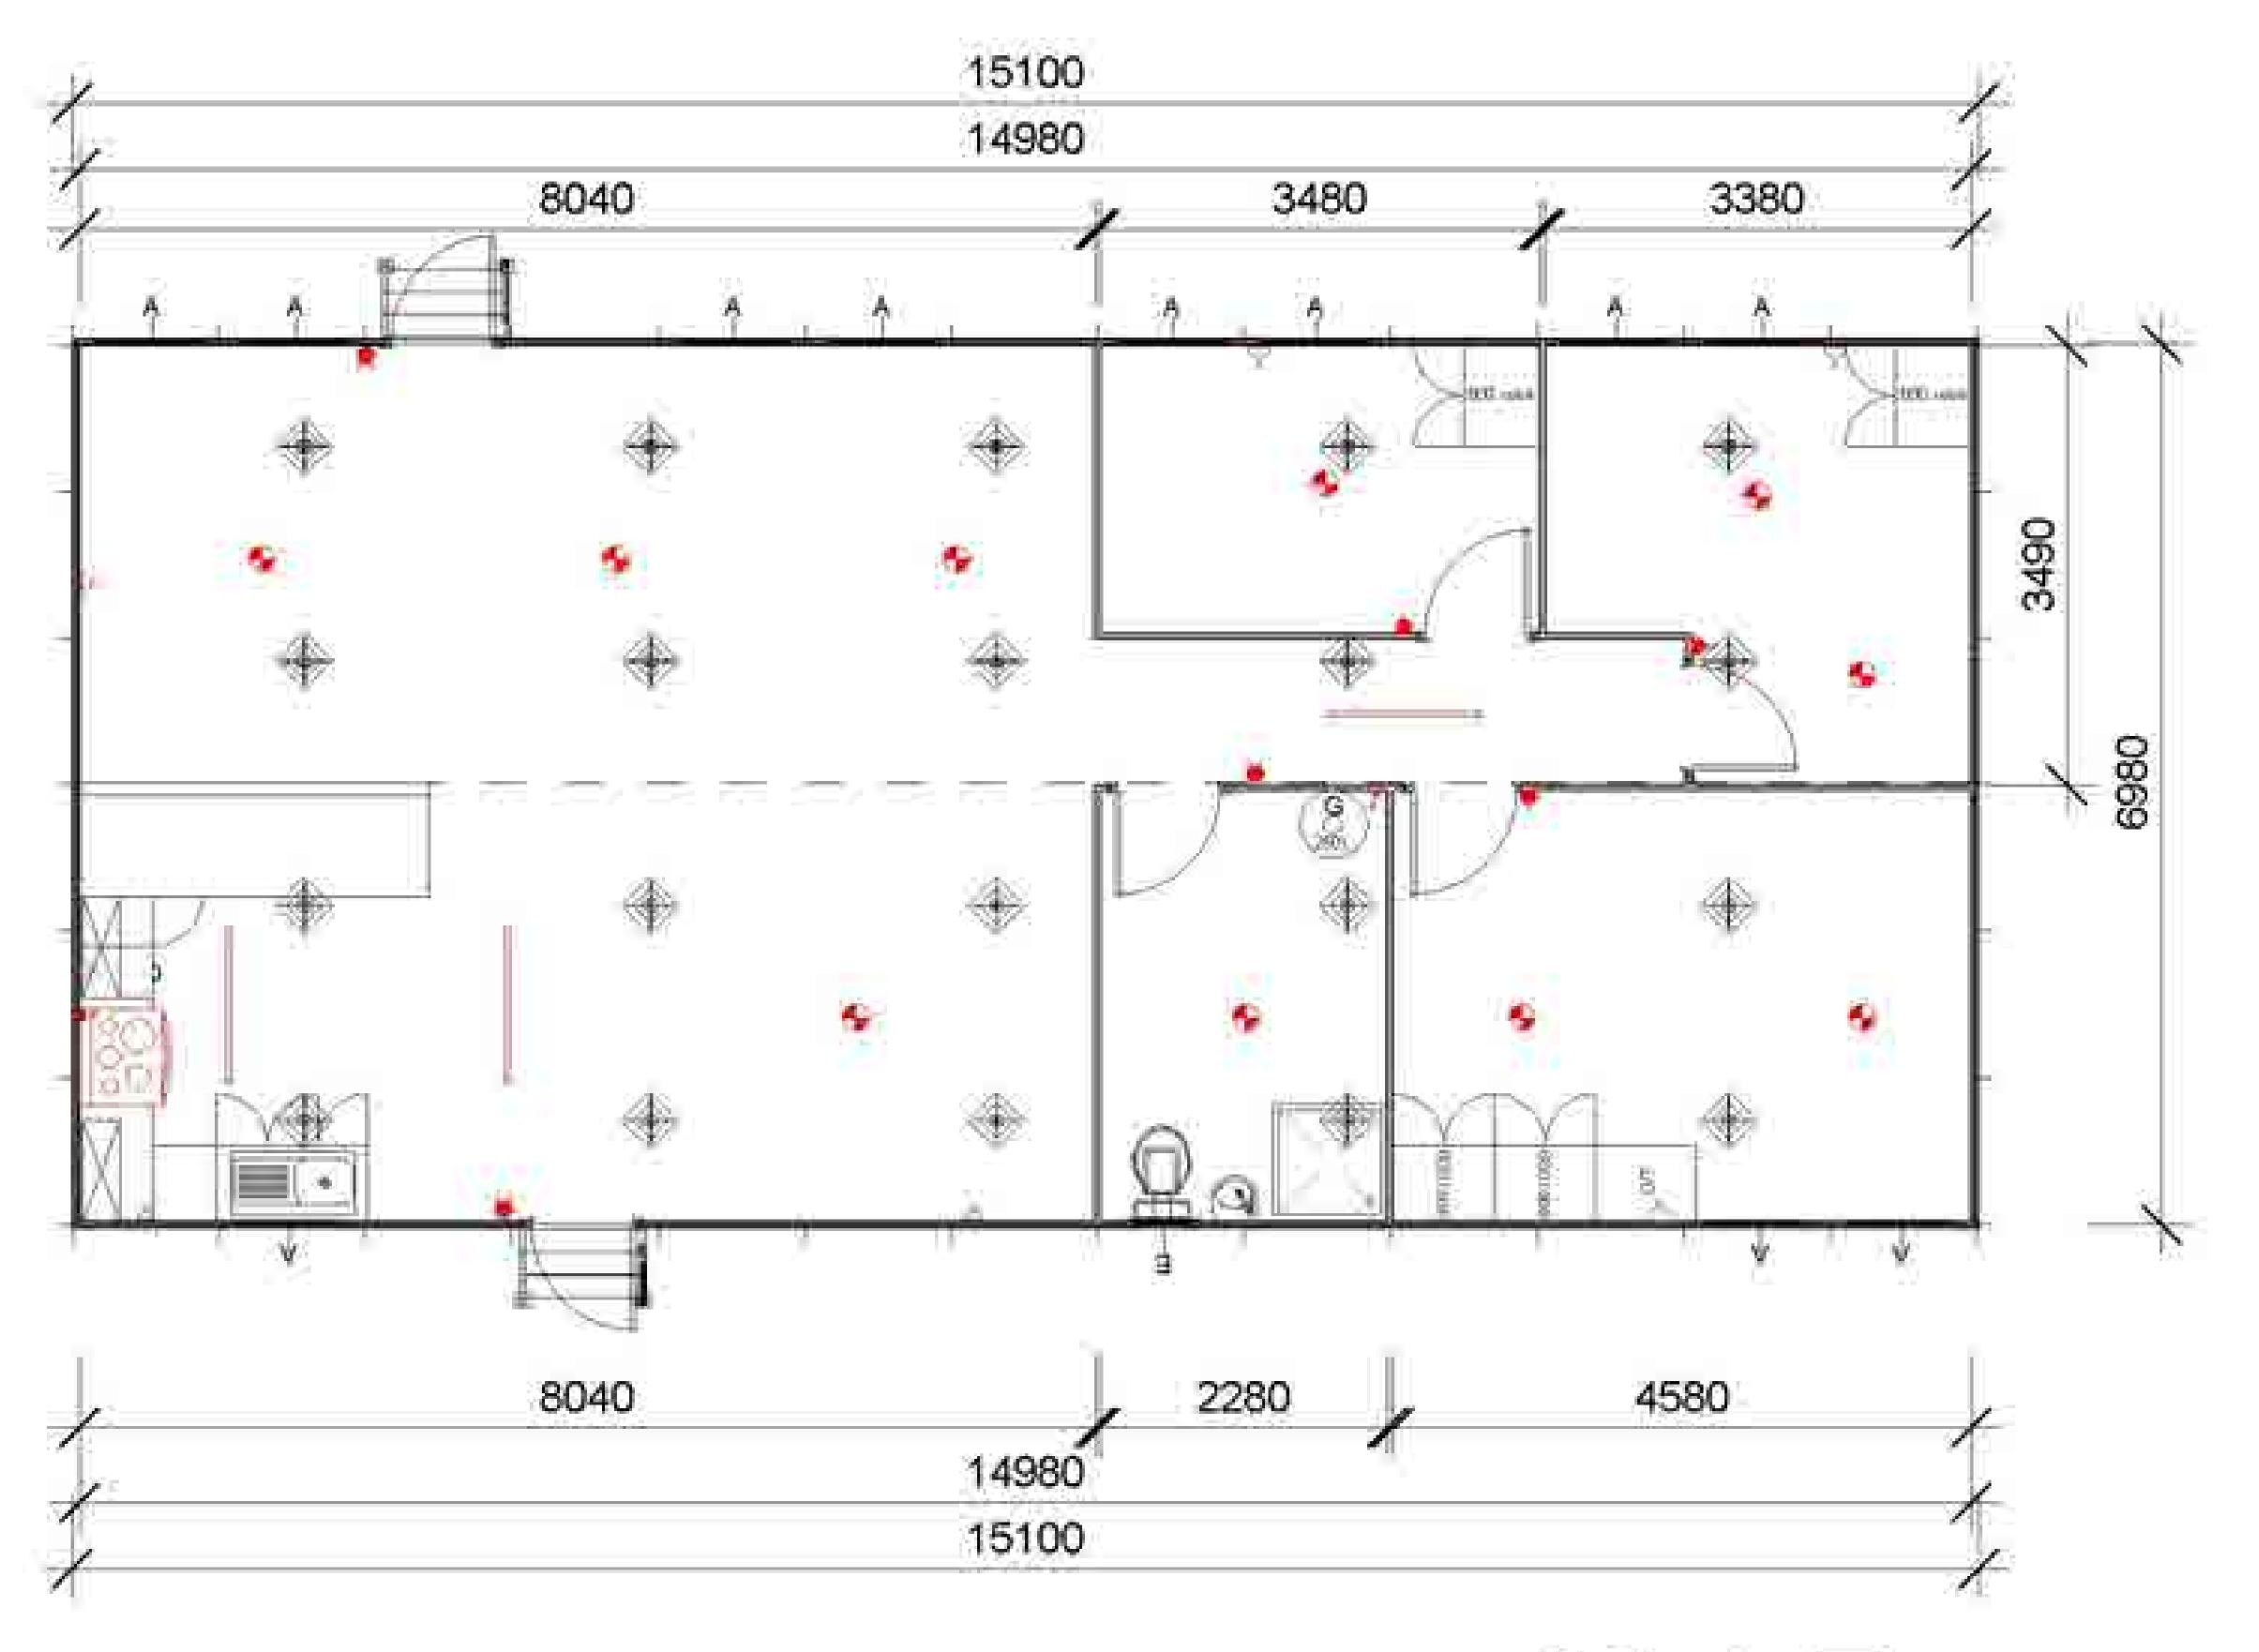

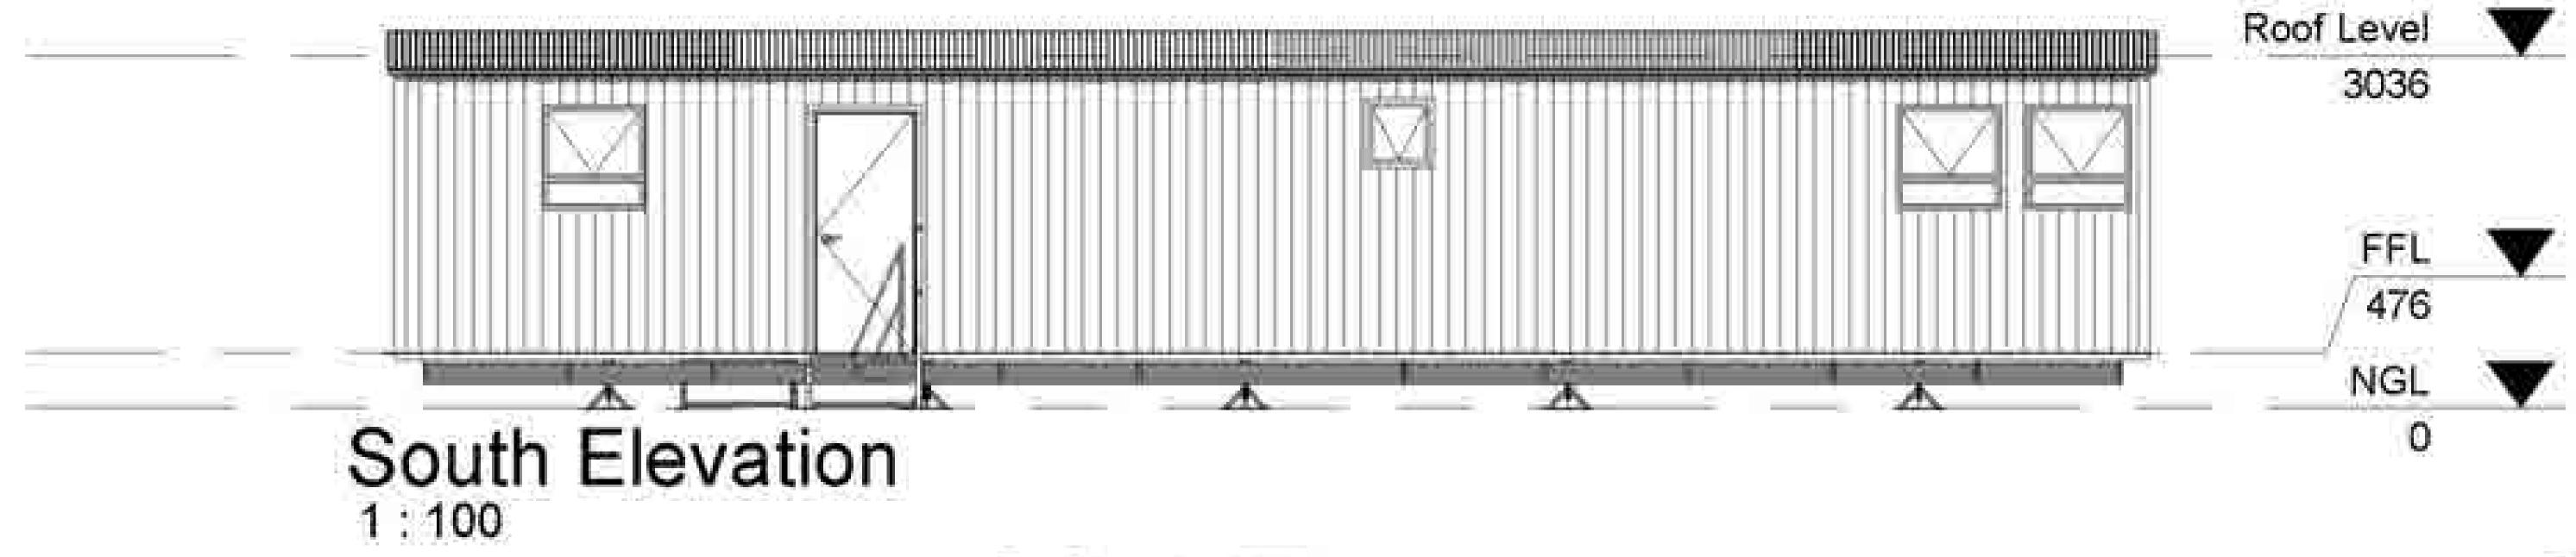

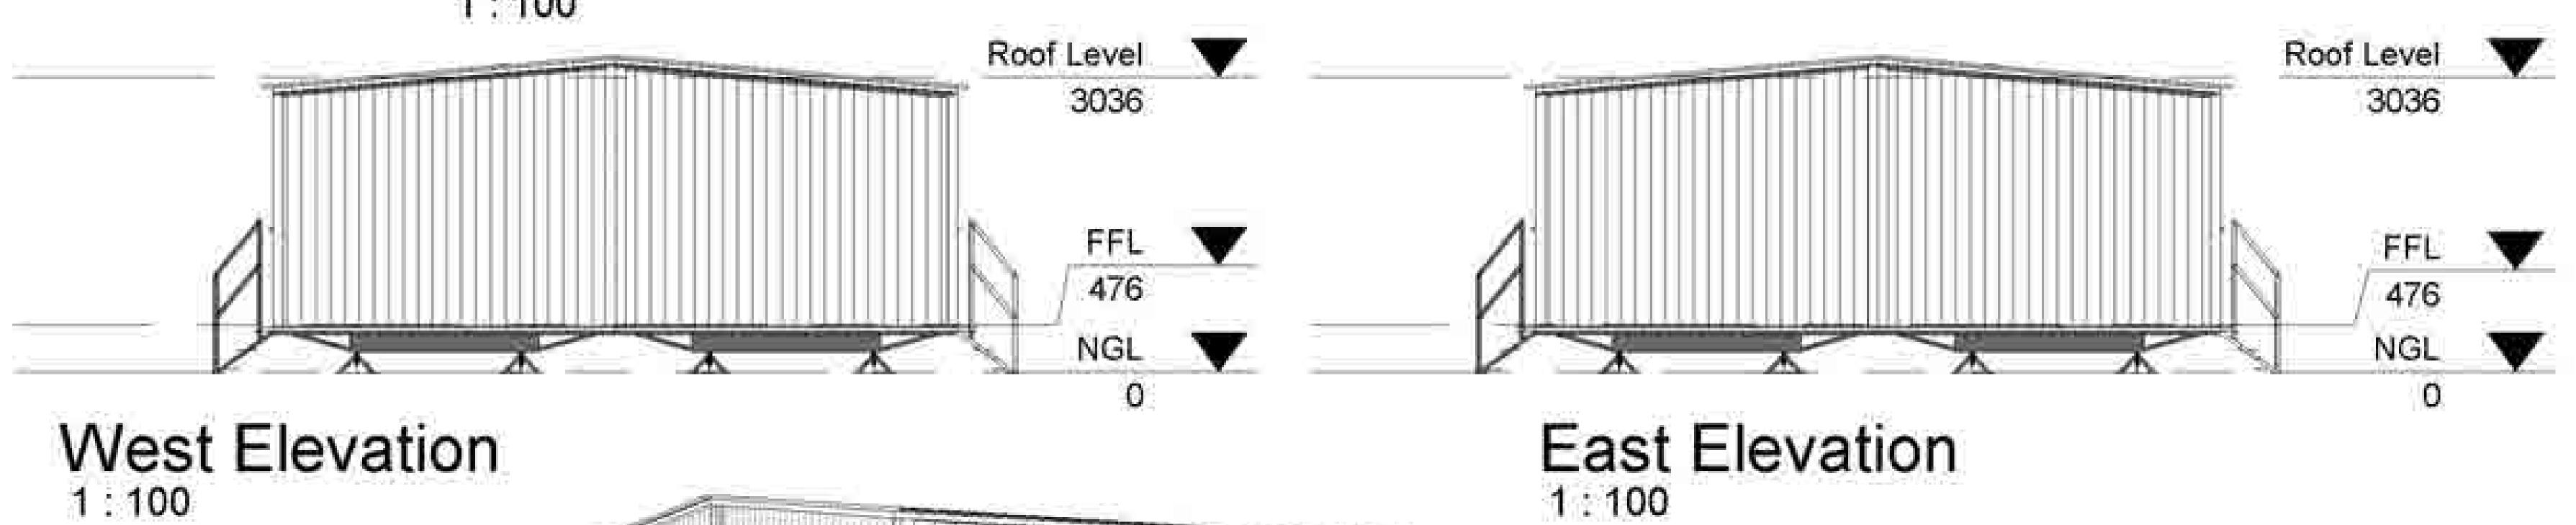

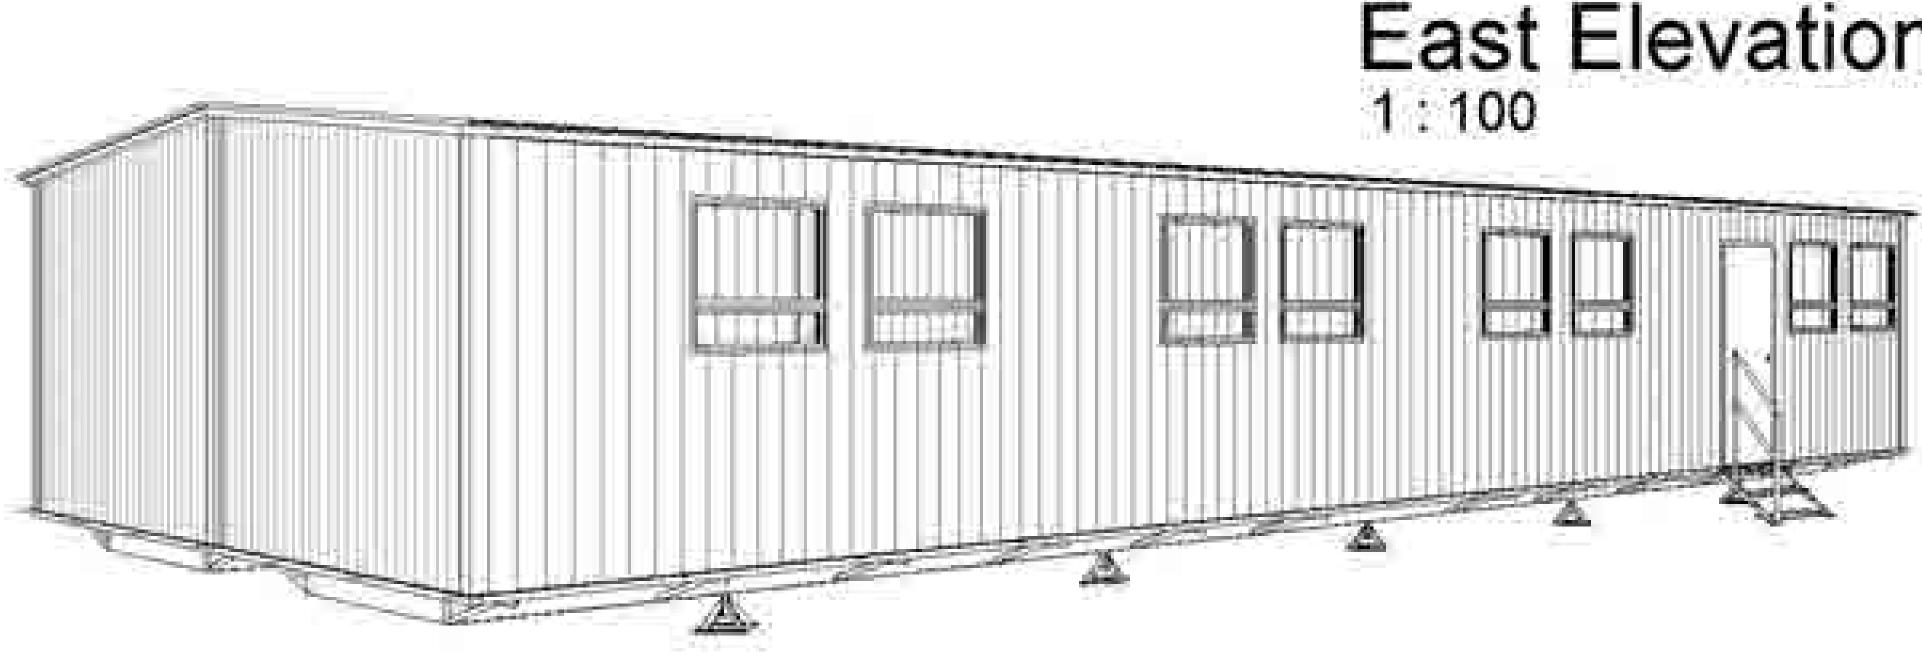




South Africa +27 11 794 1340

Botswana +267 391 2537

Zambia +260 96 034 9463

Email: sales@speedspace.co.za

Website: www.speedspace.co.za

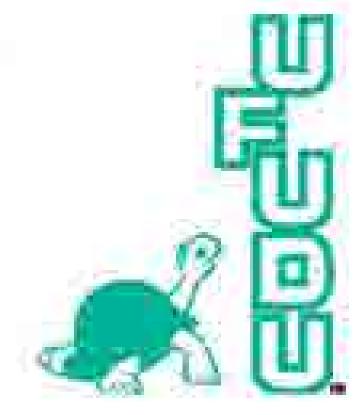

Drawing Information	Project Information
RESIDENTIAL UNIT	Client Name
scale	Project Address
rawing Number S15D3B1	
evision Number:	Drawn By:


FOR INFORMATION ONLY

Date 25/08/2016 04:44:12 PM

Electrical Fixture	
Description	Count
Isolator Stove	
Light Flour. Double 1.200m Open Channel	
Light Internal Round Flat Bowl JD90	7
Plug Double 16Amp	2
Plug Single 16Amp	3
Switch light 1 x 1 lever Complete With Cover	4
Switch Light 1 x 2 Lever Complete With Cover	

Plumbing Fixture Schedule	
Description	Count
Geyser Electric 250L Complete With Plumbing	1
Shower x 1 Complete With Plumbing/Curtain & Partition	1
Sink 1.200m Single Bowl Complete With Cupboards & Plumbing	1
Wash Hand Basin Porcelain Pedestal Complete With Plumbing -H& C water	1
WC Porcelain Close Couple Complete with Plumbing No Cubicle	1

Description	Count
Door (Chromadek) Single Complete excluding Panel	2
Door (Hollow Core) Single Complete excluding Panel	3

 




South Africa +27 11 794 1340

Botswana +267 391 2537

Zambia +260 96 034 9463

Email: sales@speedspace.co.za

Website: www.speedspace.co.za

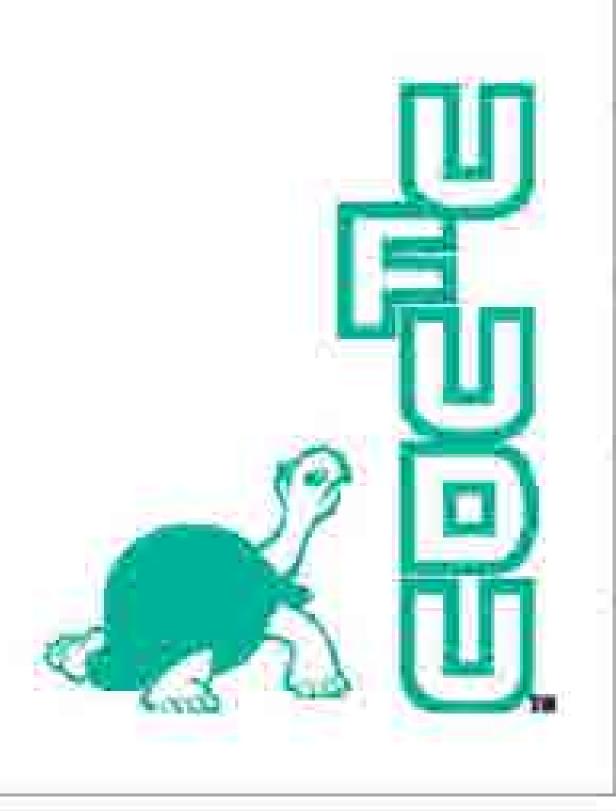

Drawing Information	Project Information
Drawing Description: RESIDENTIAL UNIT	Client Name:
Scale:	Project Address:
Drawing Number: S15S3B1	
Revision Number:	Drawn By:

FOR INFORMATION ONLY
THIS DRAWING IS THE PROPERTY OF SPEED SPACE. THE INFOMATION CONTAINED HEREIN IS PROPRIETARY AND CONFIDENTIAL. THIS IS A CONTROLLED DRAWING & UNAUTHORIZED COPYING IS NOT PERMISSIBLE

2016/08/25 04:41:34 PM

olo specklulaln


speal | a m

wfwde abin

Electrical Fixture	
Description	Count
Distribution Board 12 Way	1
Isolator Stove	1
Light Flour. Double 1.200m Open Channel	1
Light Internal Round Flat Bowl JD90	7
Plug Double 16Amp	2
Plug Single 16Amp	3
Switch light 1 x 1 lever Complete With Cover	5
Switch Light 1 x 2 Lever Complete With Cover	1


Description	Coun
Geyser Electric 250L Complete With Plumbing	1
Shower x 1 Complete With Plumbing/Curtain & Partition	1
Sink 1.200m Single Bowl Complete With Cupboards & Plumbing	1
Wash Hand Basin Porcelain Pedestal Complete With Plumbing -H& C water	1
WC Porcelain Close Couple Complete with Plumbing No Cubicle	1

Door	
Description	Count
Door (Chromadek) Single Complete excluding Panel	2
Door (Hollow Core) Single Complete excluding Panel	4

 



South Africa +27 11 794 1340 Botswana +267 391 2537 Zambia +260 96 034 9463 Email: sales@speedspace.co.za Website: www.speedspace.co.za

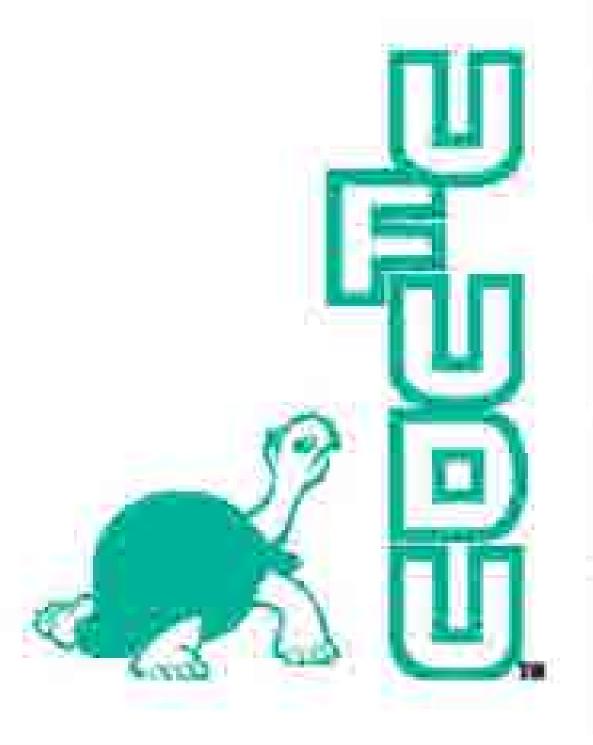

Drawing Information	Project Information
Drawing Description: RESIDENTIAL UNIT	Client Name:
Scale:	Project Address:
Drawing Number: S15S3B1	
Revision Number:	Drawn By:

FOR INFORMATION ONLY THIS DRAWING IS THE PROPERTY OF SPEED SPACE. THE INFOMATION CONTAINED HEREIN IS PROPRIETARY AND CONFIDENTIAL. THIS IS A CONTROLLED DRAWING & UNAUTHORIZED COPYING IS NOT PERMISSIBLE


2016/08/25 04:42:40 PM

speed file speculo le

speed plain

speed | a m

 unfrued & albind



specul olole

speed filee

speed leep

speed plain

speed | a m

wfwdle abin



Furniture Schedule

Description

Draw unit (4 Drawer)

Robe Unit 800mm

Wall Unit 400mm

Wall Unit 800mm

1:100

Dressing table c/w drawer

Description	Count
Geyser Electric 250L Complete With Plumbing	1
Shower x 1 Complete With Plumbing/Curtain & Partition	1
Sink 1.200m Single Bowl Complete With Cupboards & Plumbing	1
Wash Hand Basin Porcelain Pedestal Complete With Plumbing -H& C water	1
WC Porcelain Close Couple Complete with Plumbing No Cubicle	1


Count


Description	Count
oor (Chromadek) Single Complete excluding Panel	2
oor (Hollow Core) Single Complete excluding Panel	3


Floor Area	
Description	Area
Vinyl Sheeting -	62 m²
MS022 Grey 2mm	
(Embossed) - MIF40	


MS022 Grey 2mm (Embossed) - MIF40	
Generic Model Sche	dule
Description	Count
3 Tier Complete With Hand Rails Single Door	2


Large Tripod Jack

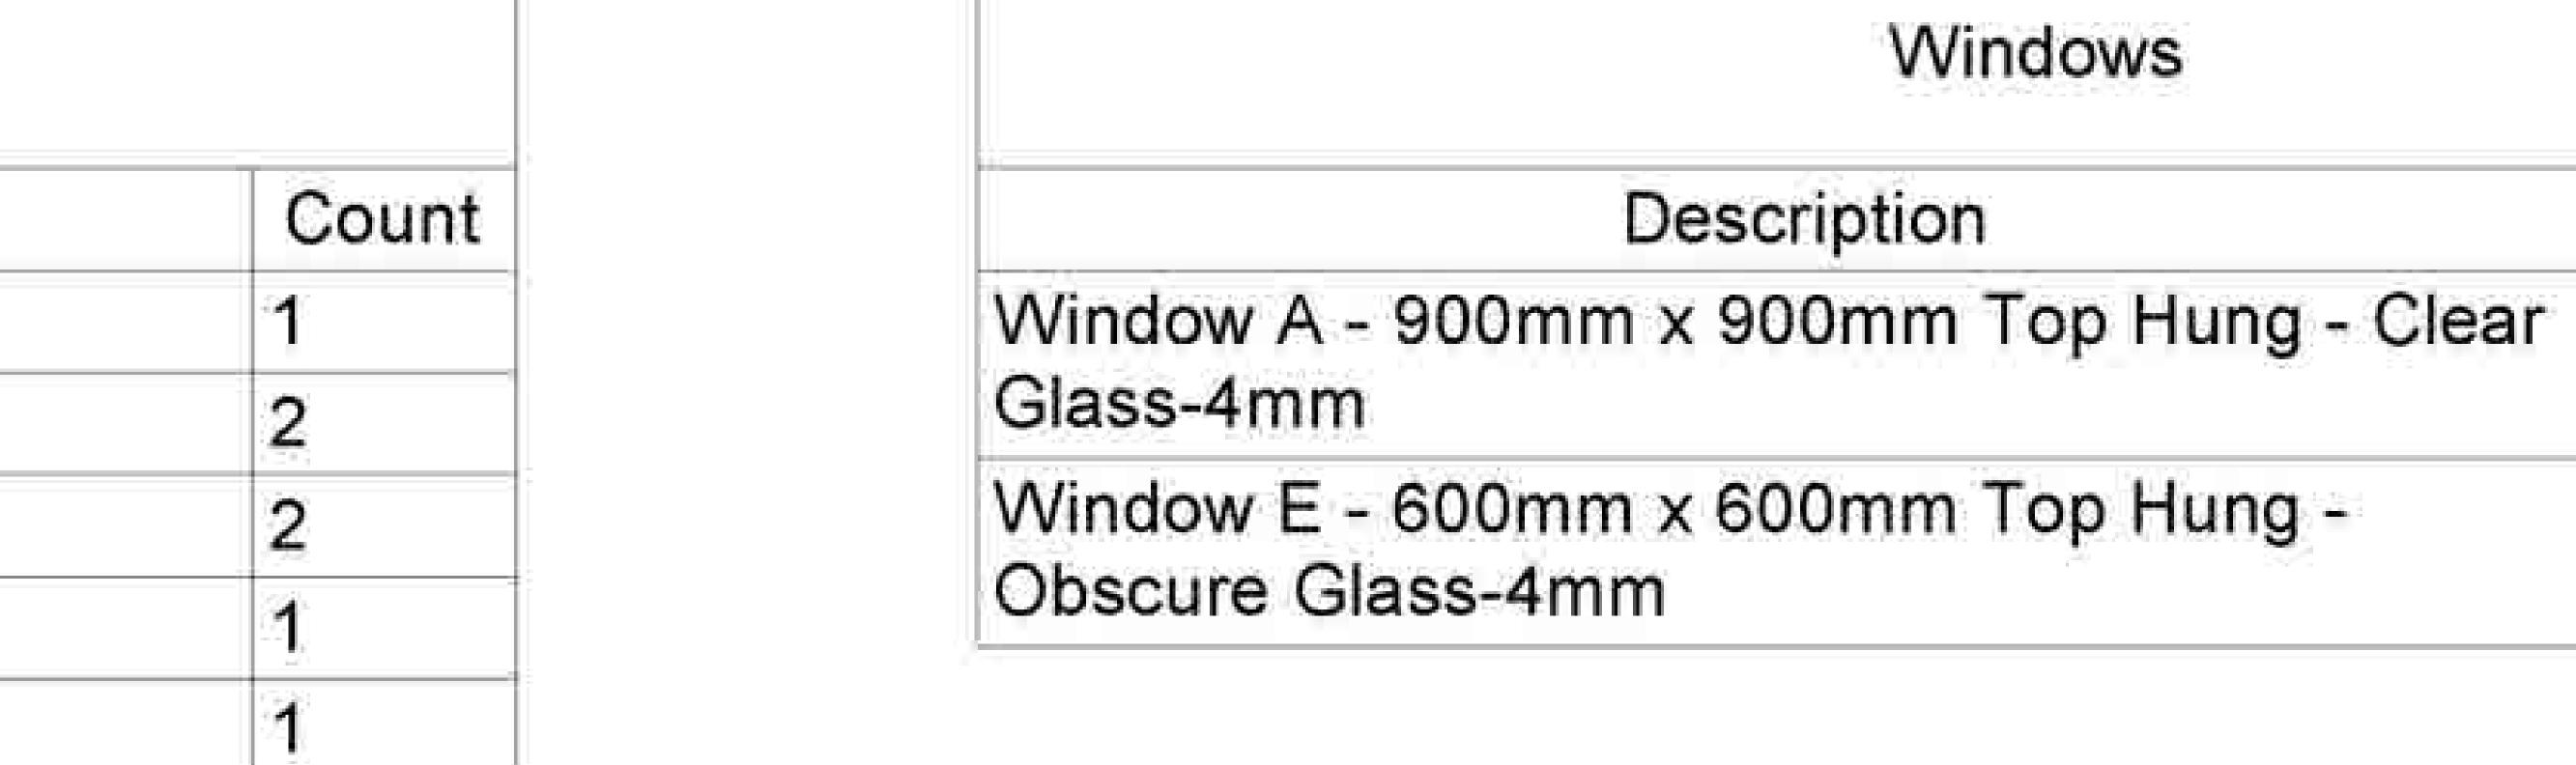

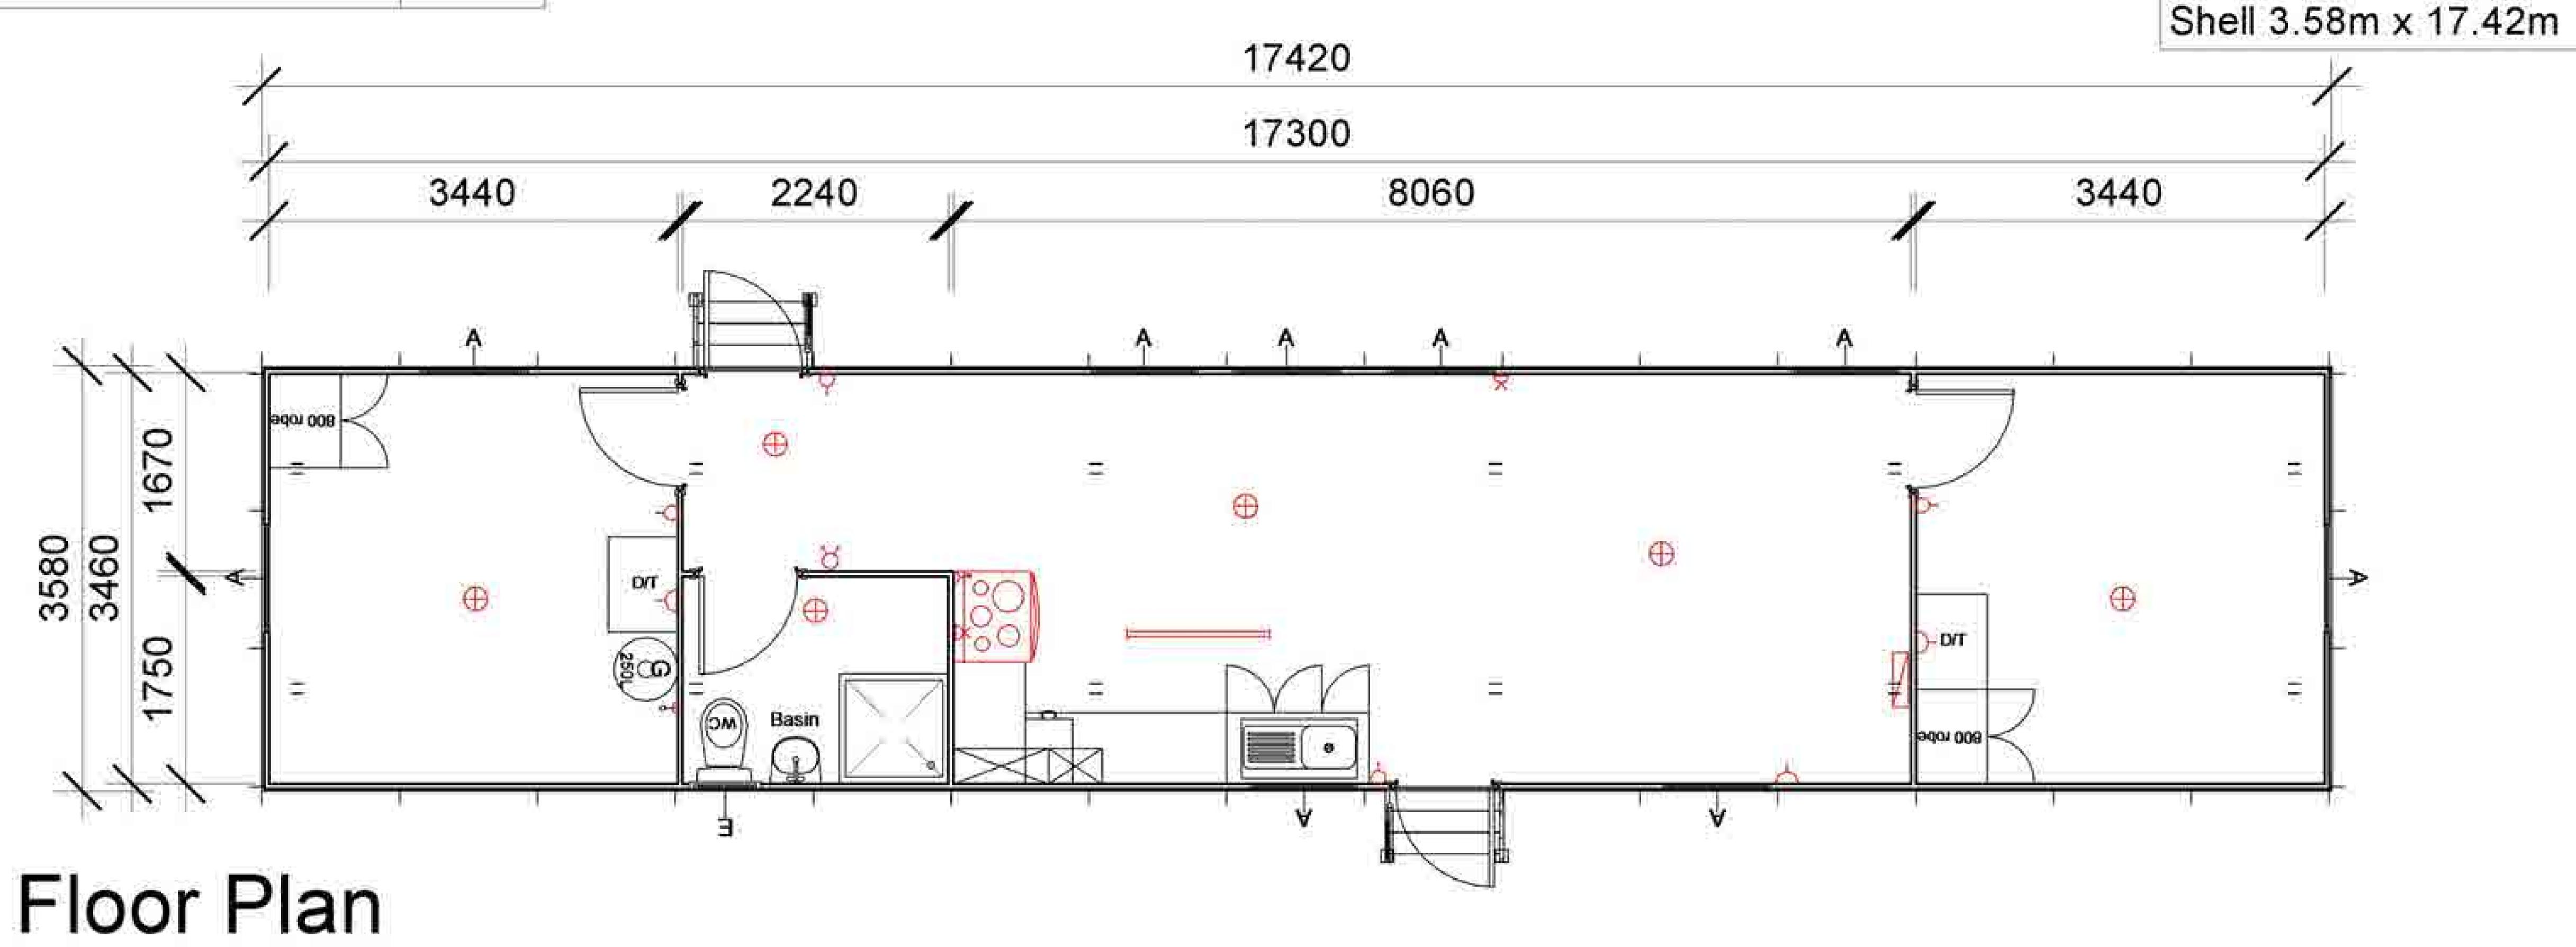

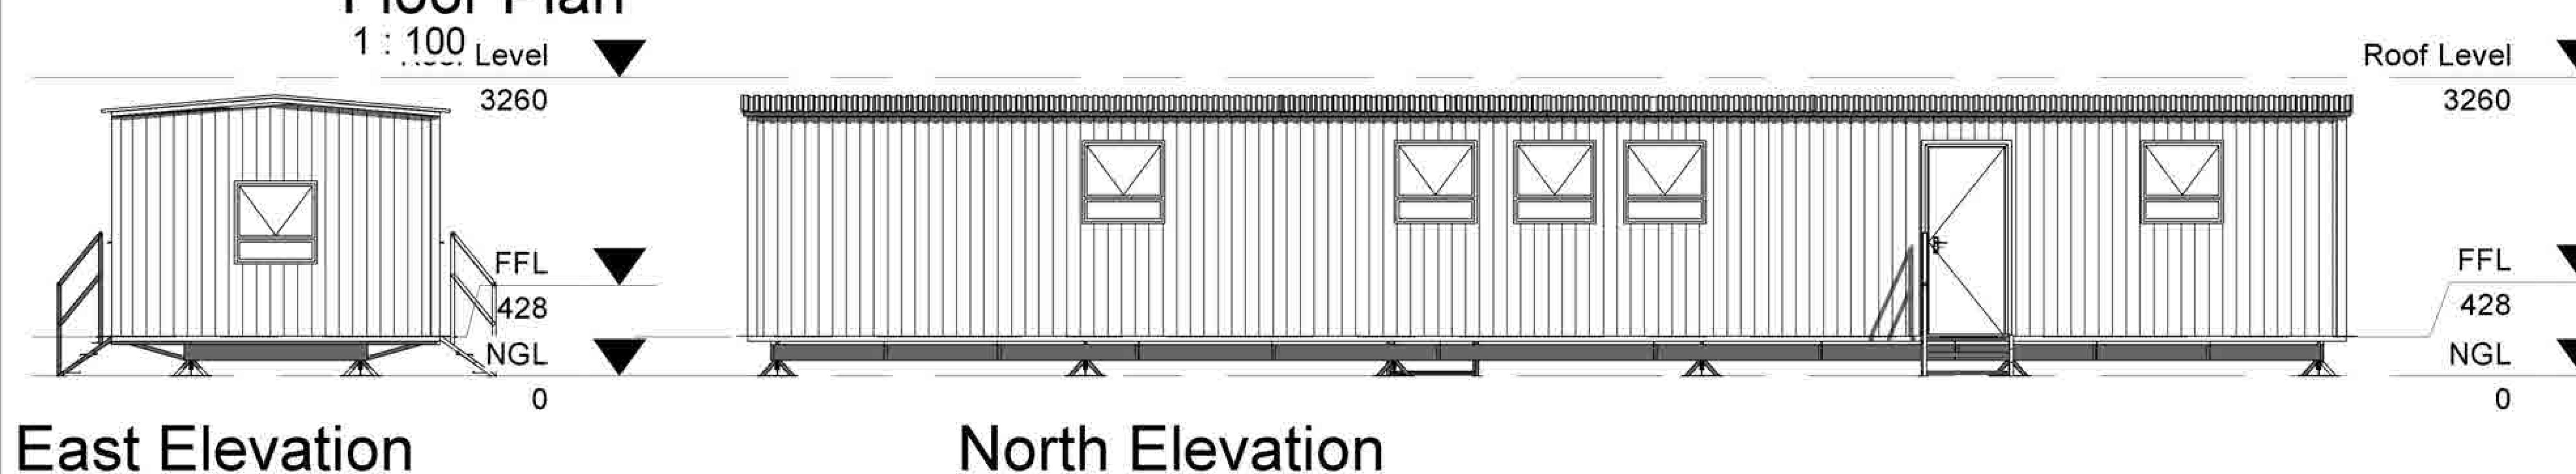

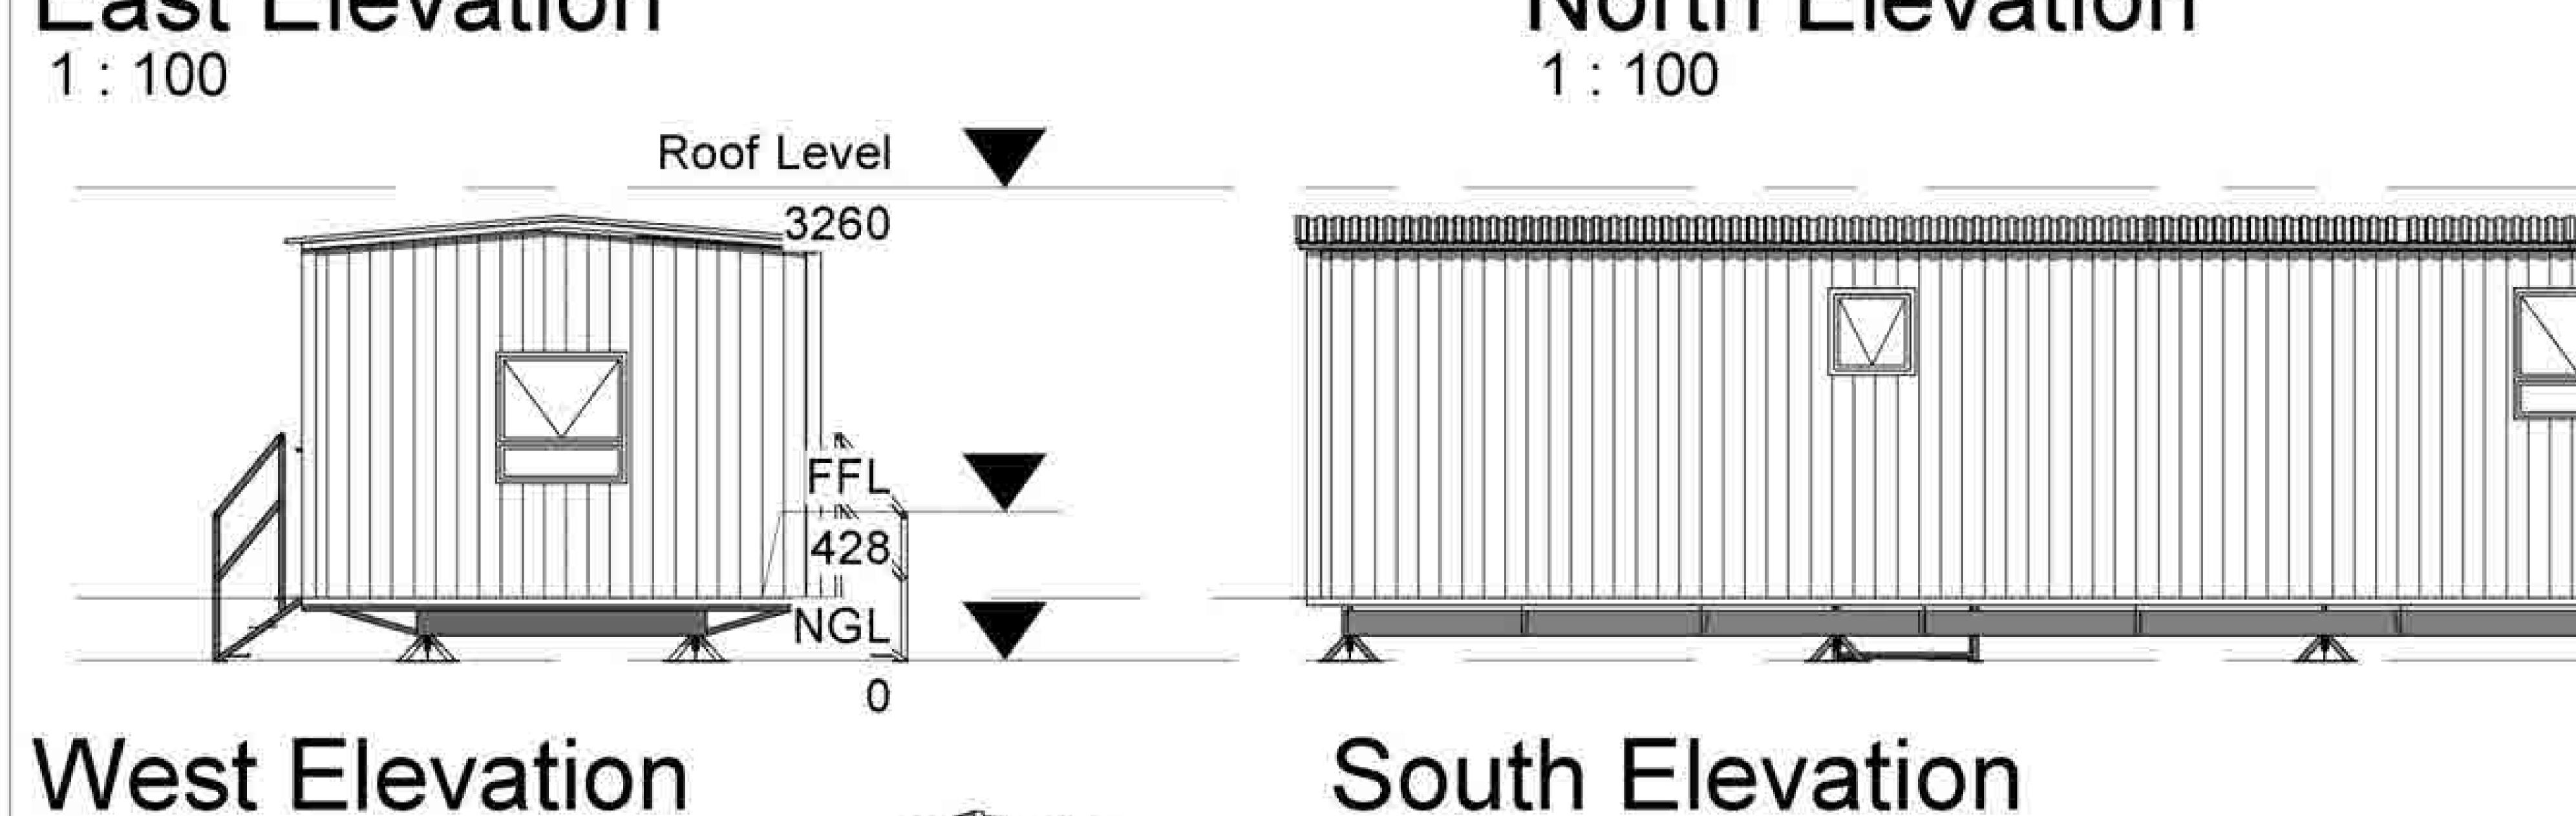

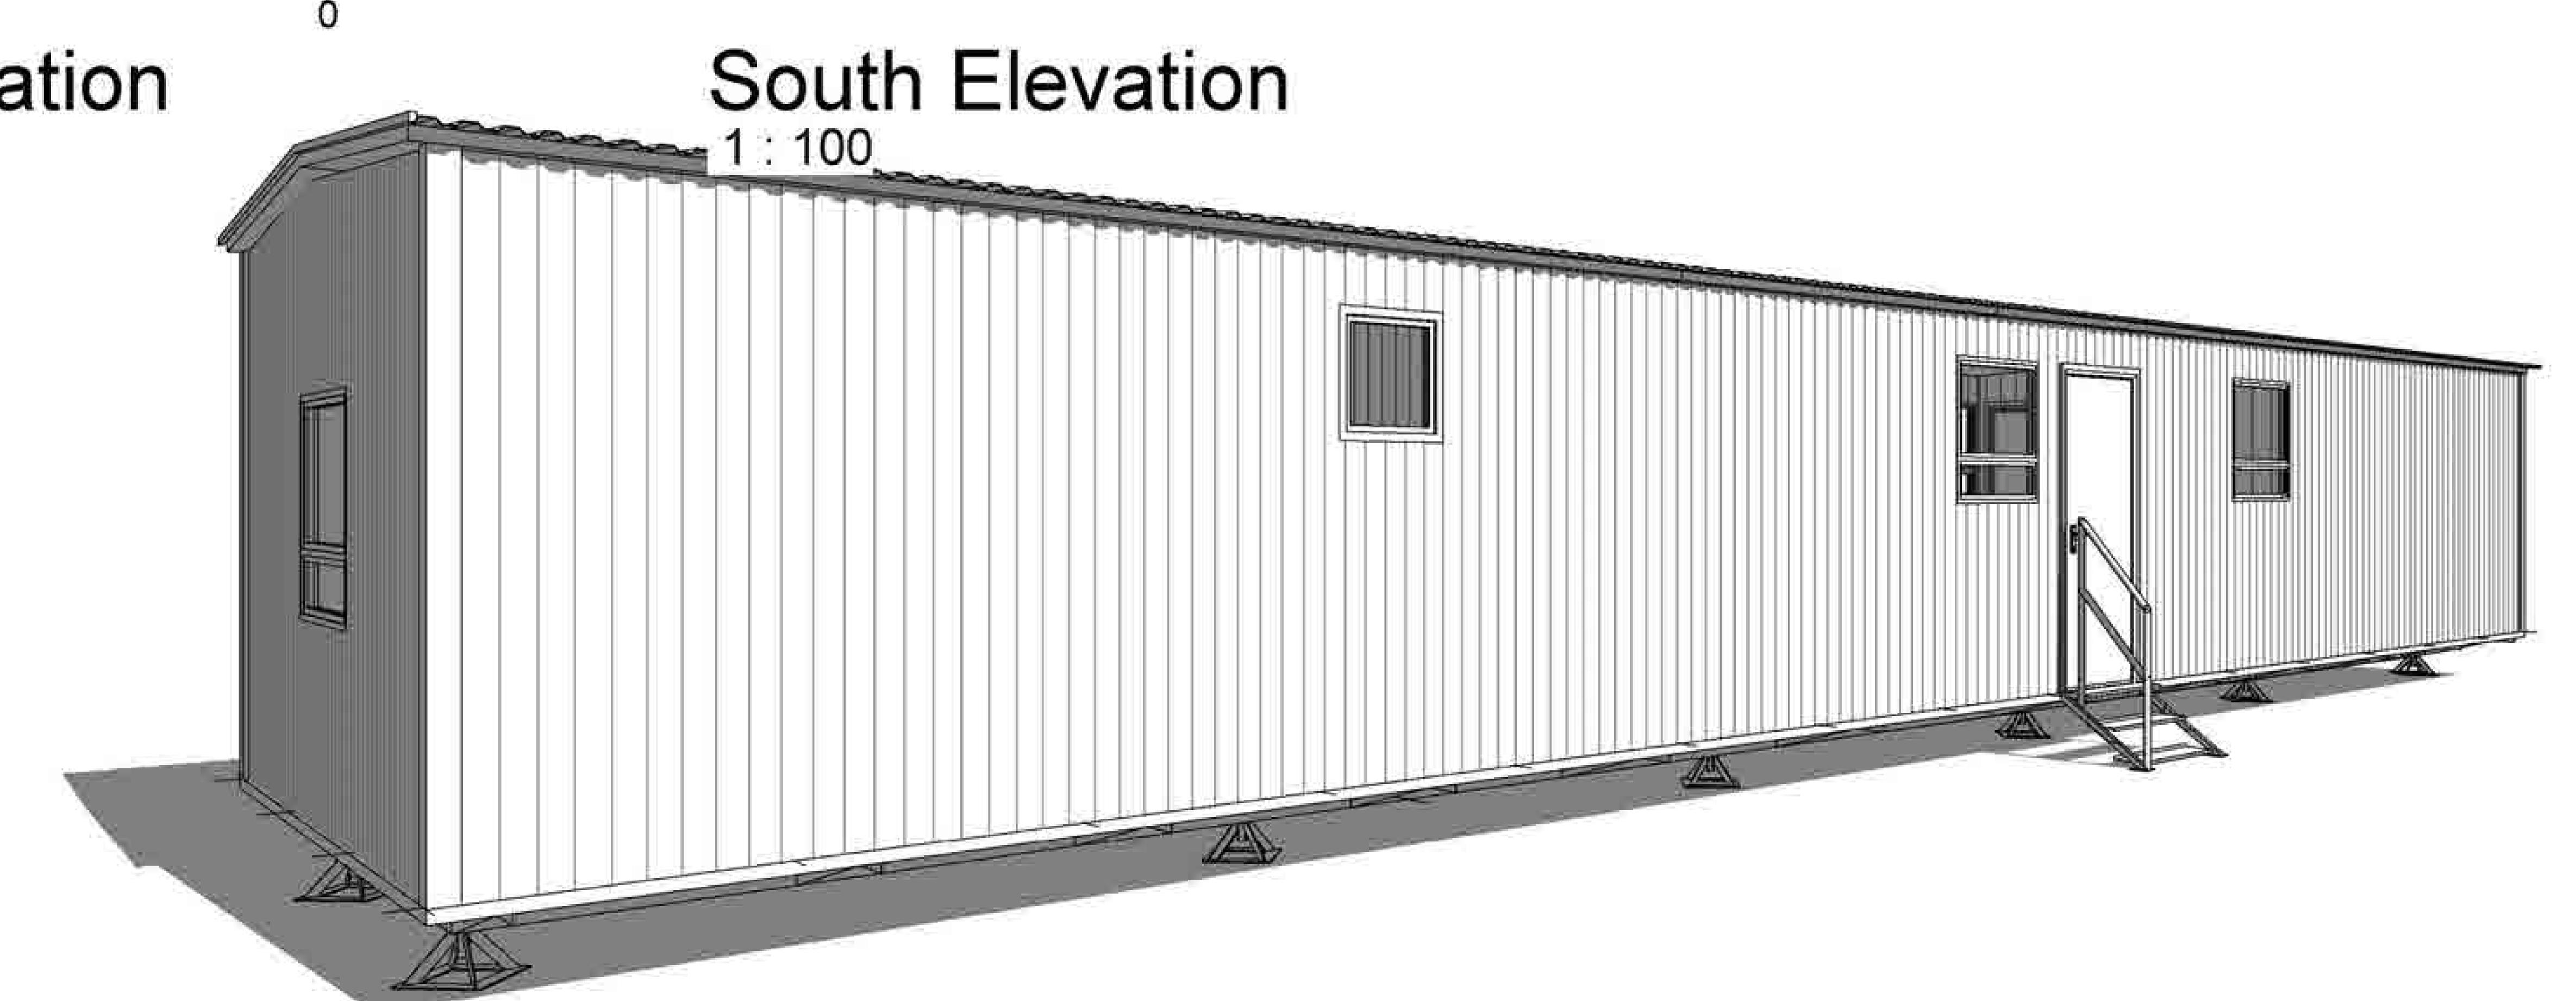




South Africa +27 11 794 1340

Botswana +267 391 2537

Zambia +260 96 034 9463

Email: sales@speedspace.co.za

Website: www.speedspace.co.za

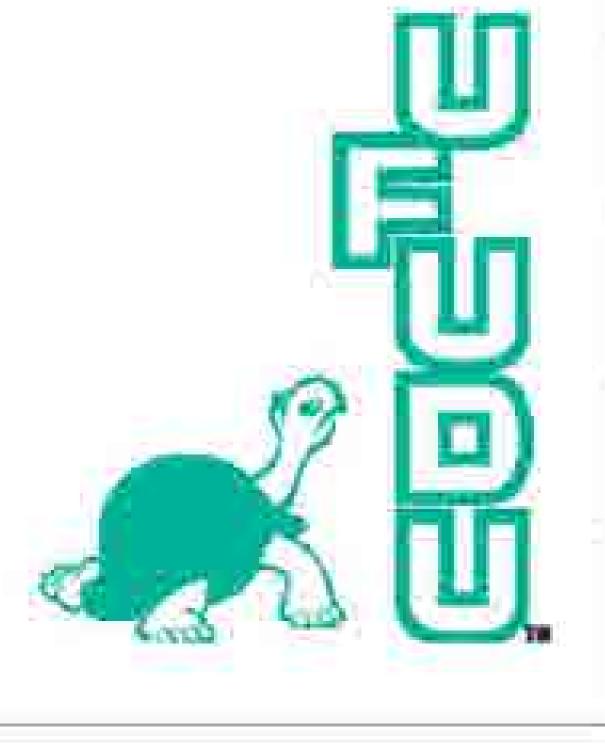

Drawing Information	Project Information
Drawing Description: RESIDENTIAL UNIT	Client Name:
Scale:	Project Address:
Drawing Number: S18S2B1	
Revision Number:	Drawn By:

FOR INFORMATION ONLY
THIS DRAWING IS THE PROPERTY OF SPEED SPACE. THE INFOMATION CONTAINED HEREIN IS PROPRIETARY AND CONFIDENTIAL. THIS IS A CONTROLLED DRAWING & UNAUTHORIZED COPYING IS NOT PERMISSIBLE

2016/08/25 04:52:16 PM



 









Roof Level





South Africa +27 11 794 1340
Botswana +267 391 2537
Zambia +260 96 034 9463
Email: sales@speedspace.co.za
Website: www.speedspace.co.za

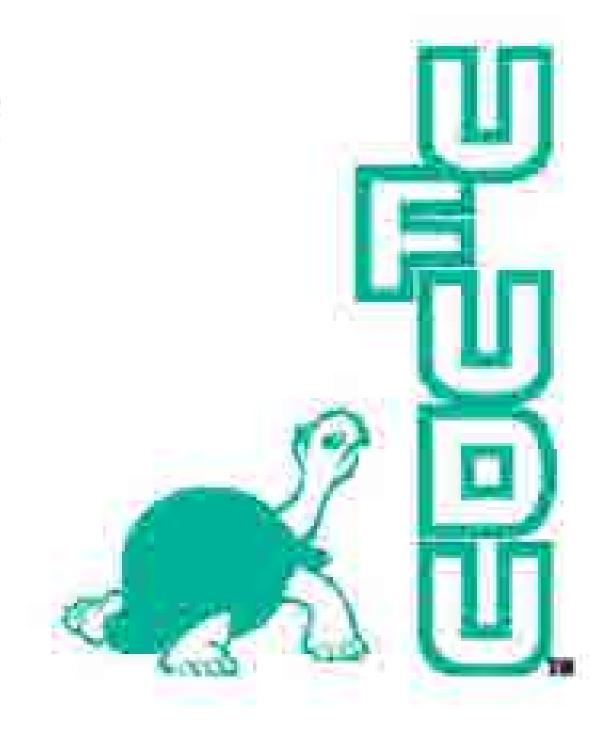

Drawing Information	Project Information
Drawing Description: RESIDENTIAL UNIT	Client Name:
Scale:	Project Address:
Drawing Number: S18S3B1	
Revision Number:	Drawn By:

FOR INFORMATION ONLY
THIS DRAWING IS THE PROPERTY OF SPEED SPACE. THE INFOMATION CONTAINED HEREIN IS PROPRIETARY AND CONFIDENTIAL. THIS IS A CONTROLLED DRAWING & UNAUTHORIZED COPYING IS NOT PERMISSIBLE

2016/08/25 04:53:58 PM














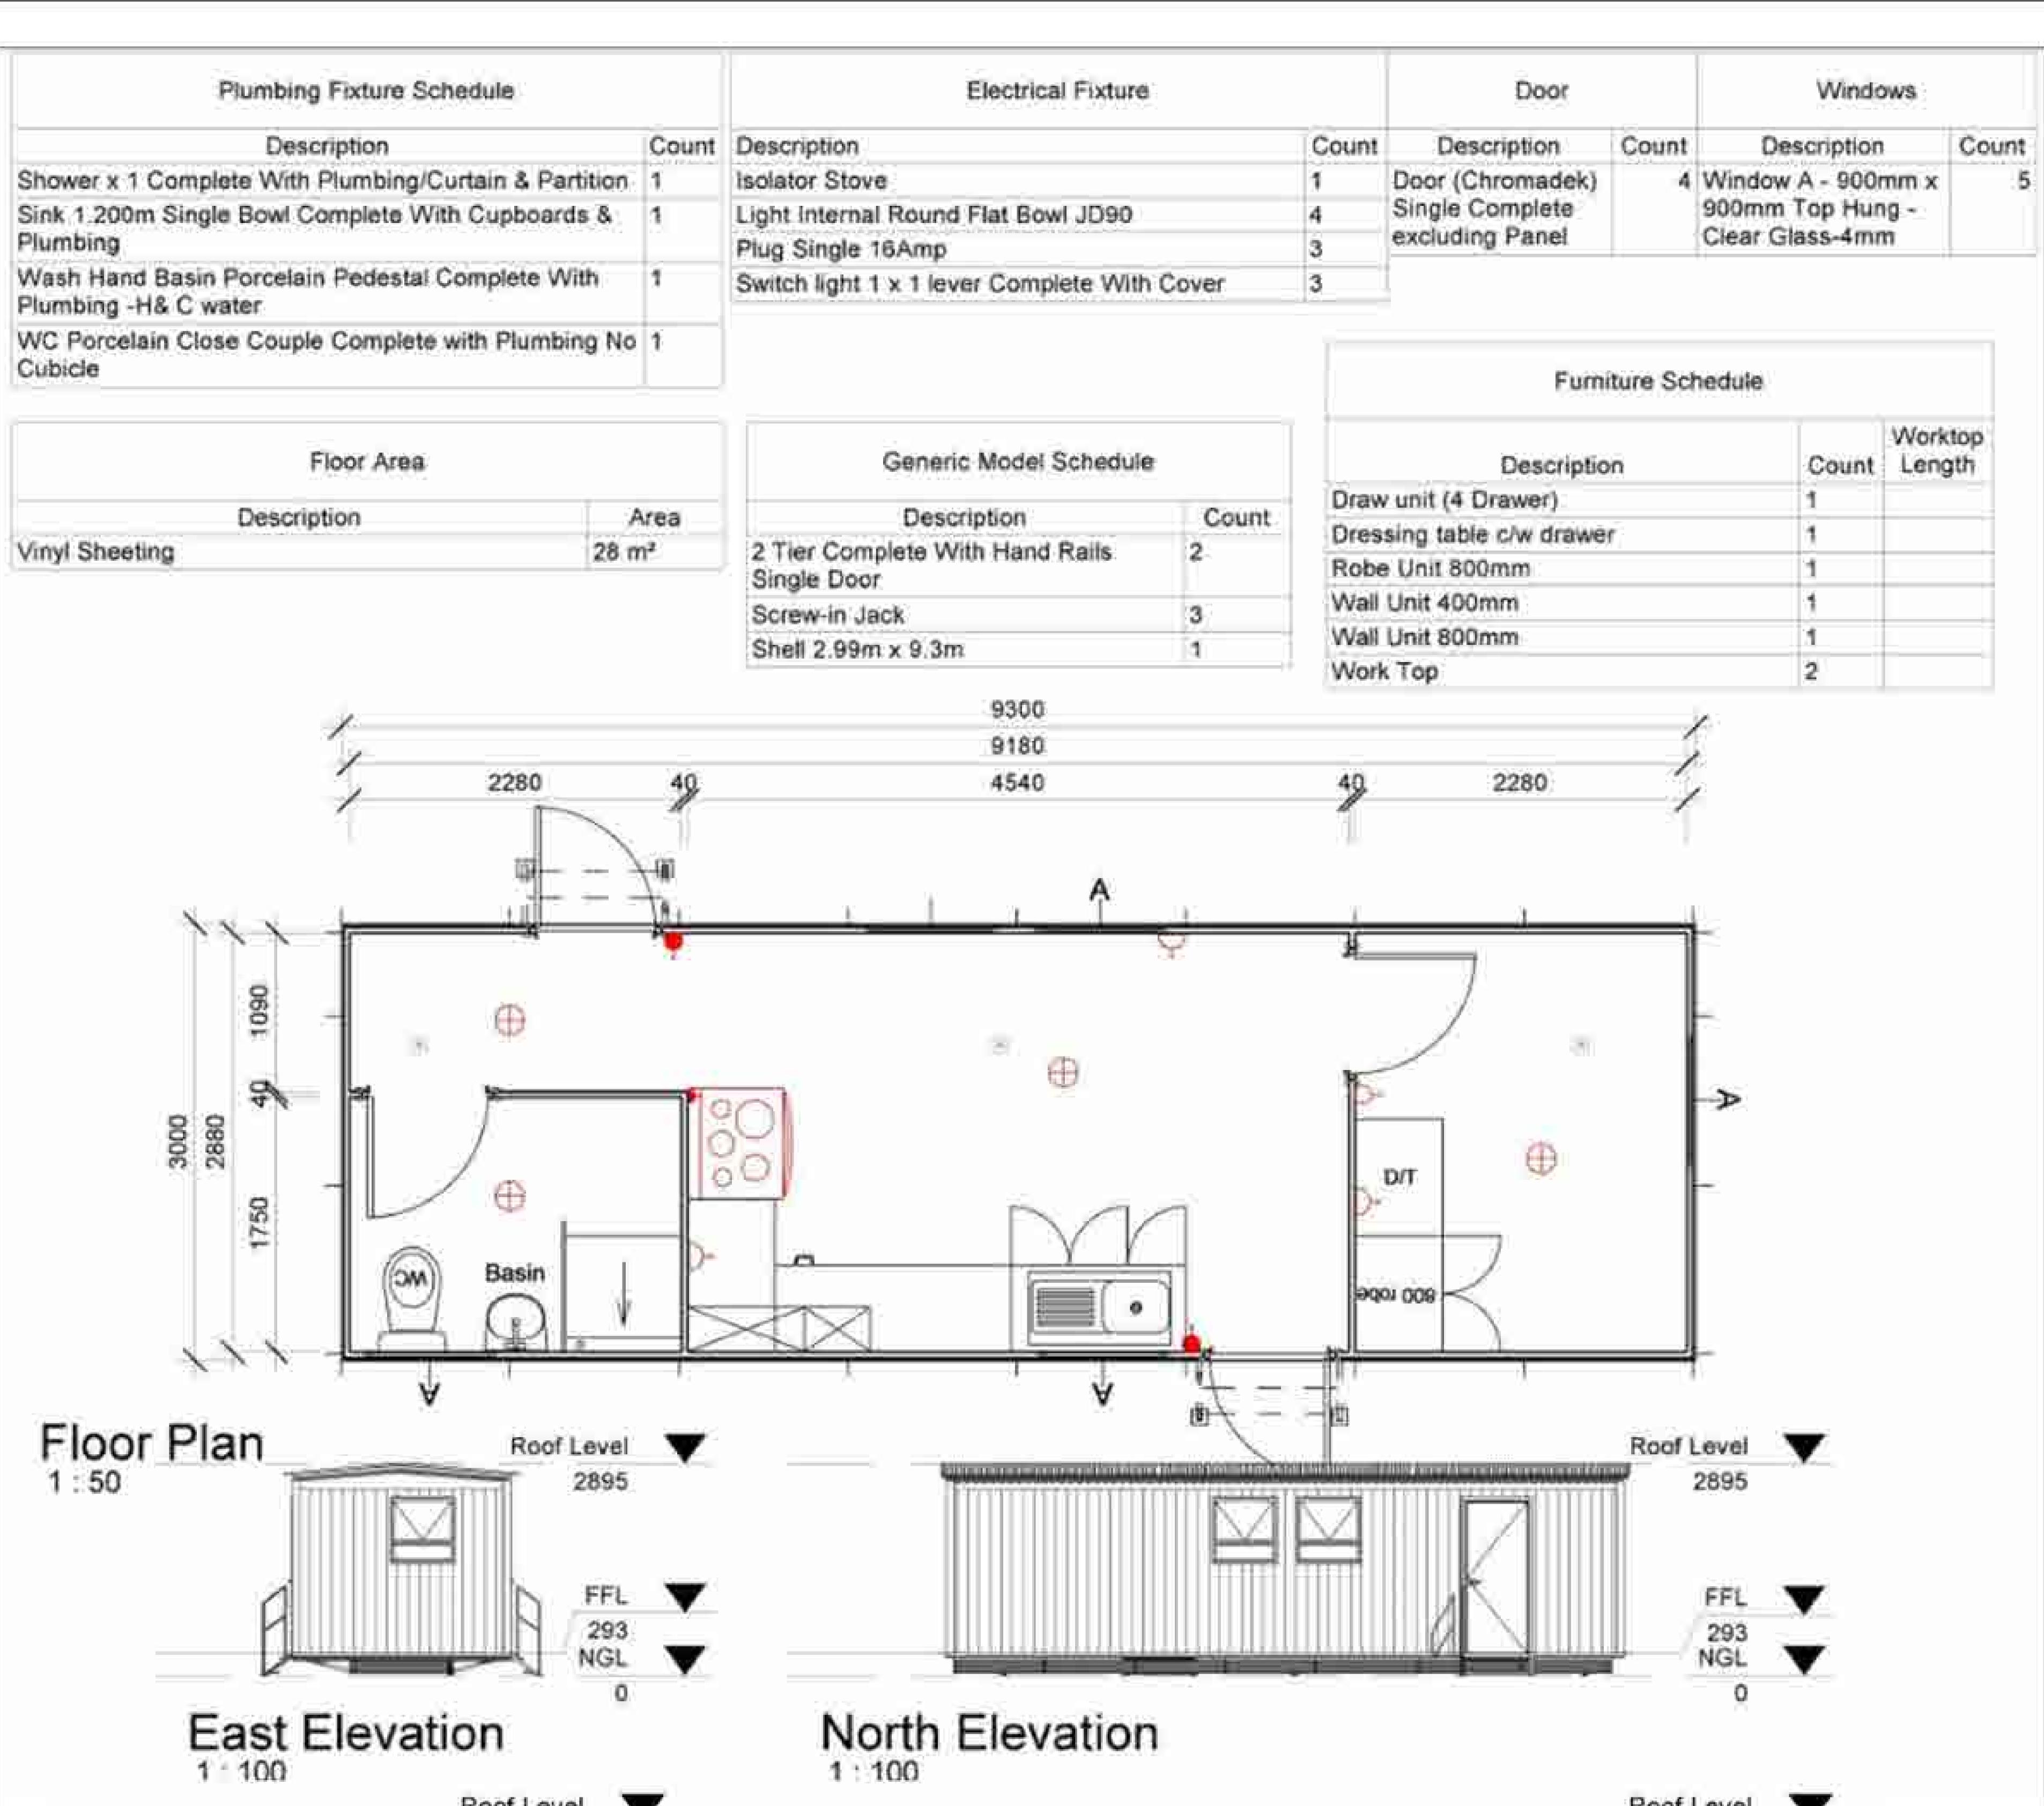

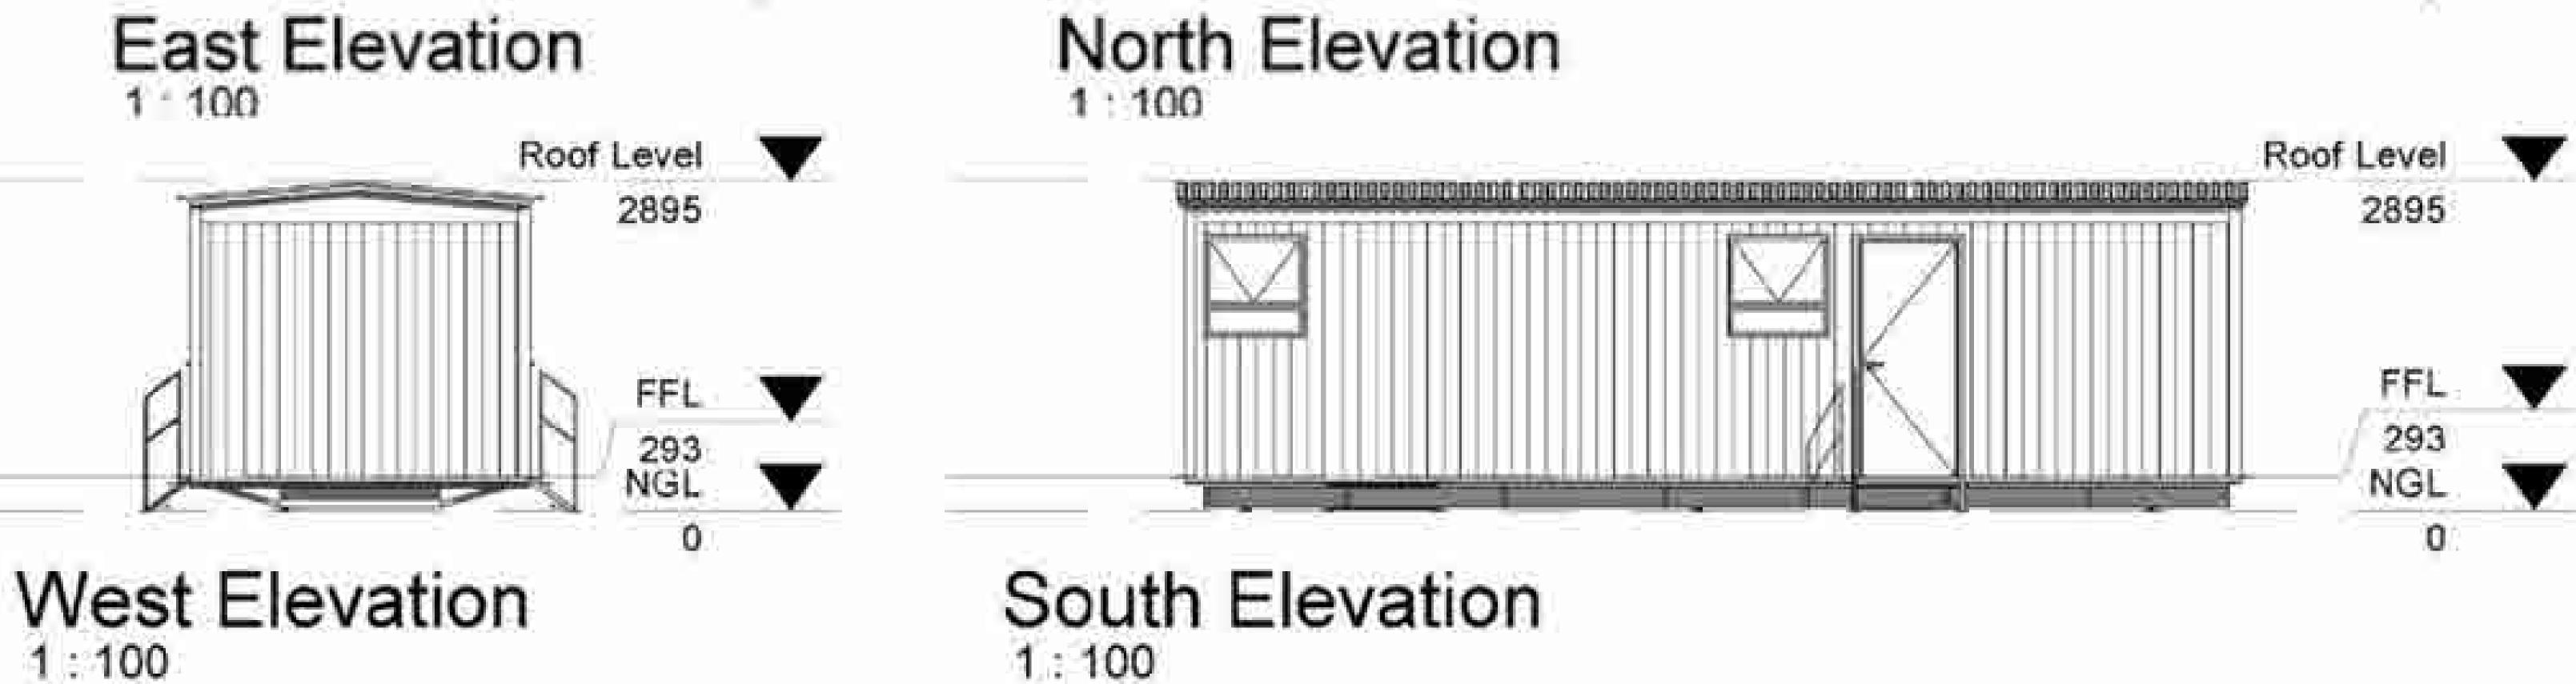


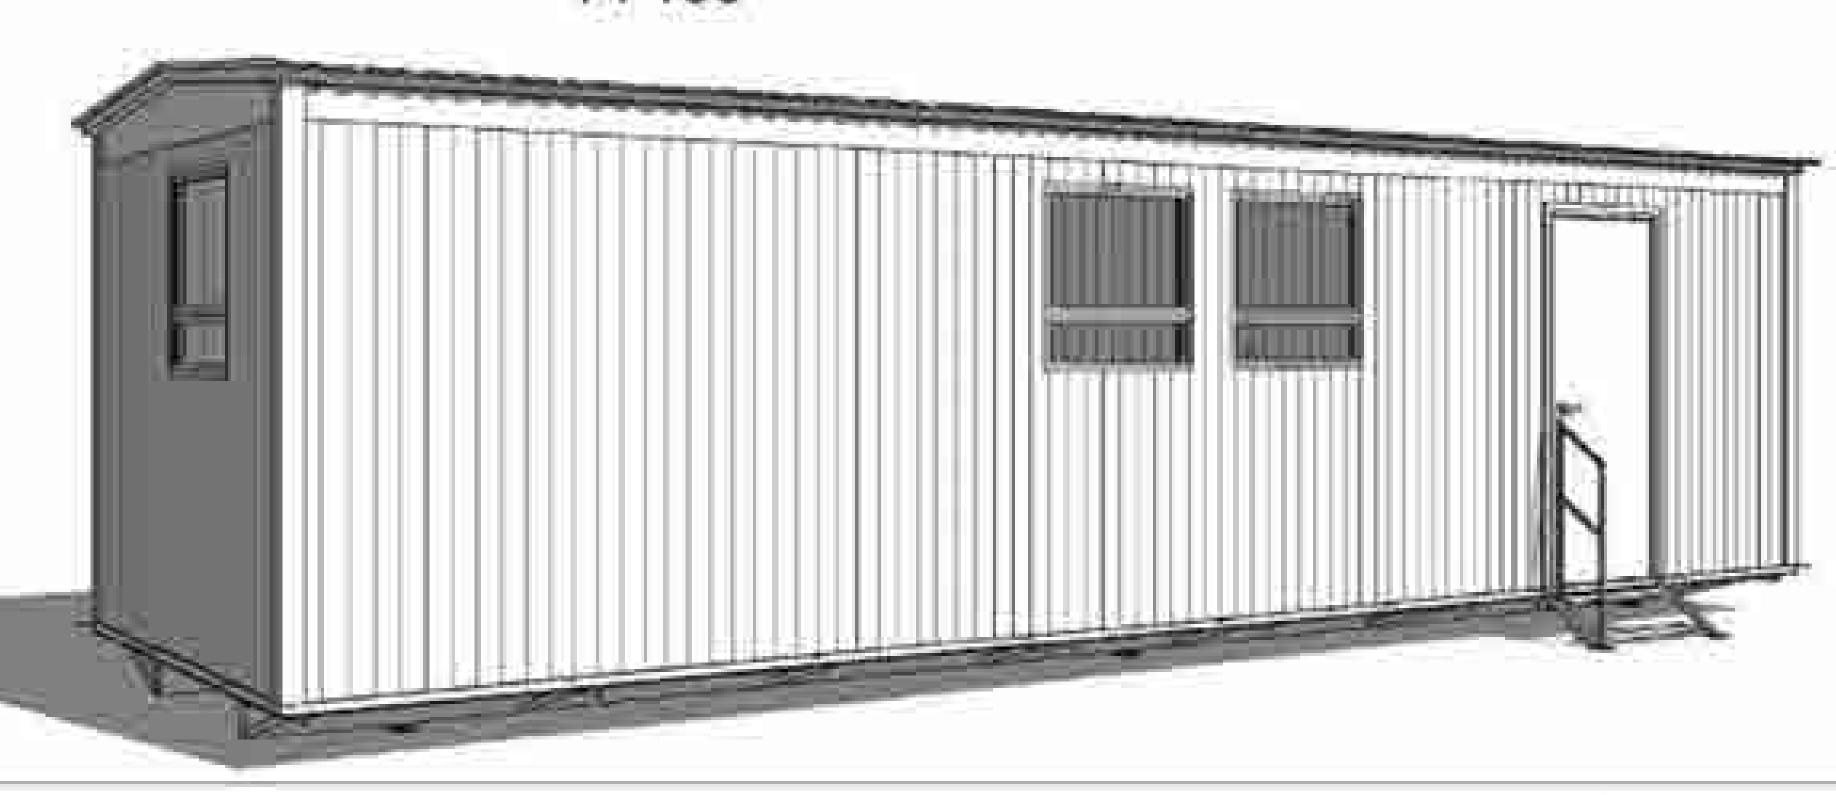



South Africa +27 11 794 1340 Botswana +267 391 3537 Zambia +260 96 034 9463

Email: sales@speedspace.co.za Website: www.speedspace.co.za

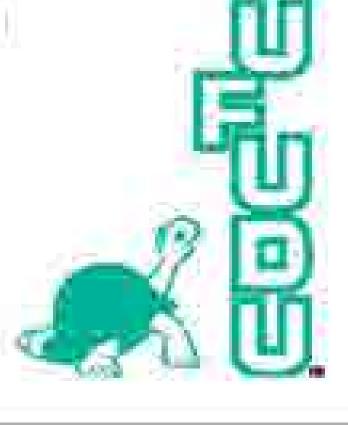

Drawing Information	Project Information
Drawing Description: Residentail Unit	Client Name
Scale	Project Address
Drawing Number S9S1B1	
Revision Number	Drawn By:

FOR INFORMATION ONLY

Date 29/08/2016 12:34:14 PM

speed sleep

Speed plan

enfinally colored